



General Notes


- All dimensions are in meters unless otherwise noted.
- All existing trees, sidewalks, curbs, catch basins, culverts, survey markers, to remain are to be protected during construction. Any damage to them is to be made good by the contractor. Maintain positive drainage into all catch basins and curb inlets.
- Contractor is to limit operations to the area within the limit of work shown on the drawing. Should areas outside of this limit be damaged during the course of construction, contractor is to make good the damage at his own expense.
- Contractor is to obtain location of all utilities prior to construction. If using power equipment to excavate contractor must notify Hydro and Gas and telephone utilities and take steps to avoid damaging their installations.
- The contract shall include all labour, material, equipment and service necessary, reasonably implied, and incidental to the complete installation of the electrical work shown on the plans and specifications. Supply and install all devices required for a approved system, operating to the complete satisfaction of the contract administrator.
- Electrical contractor is to prepare and submit to the proper authorities all information necessary for, and to obtain any necessary permits and pay all permit fees.
- The electrical contractor shall carefully examine all drawings related to the work to ensure that the work under this contract can be carried out and, prior to the submission of his/her tender, report at once to the Contract Administrator any defect, discrepancy, omission or interference affecting the electrical work or the guarantee of same.
- The entire electrical installation shall comply with the latest edition of the Canadian Electrical Code and with all applicable provincial and municipal laws, rules, and ordinances.
- The contract shall include all labour, material, equipment and service necessary, reasonably implied, and incidental to the complete installation of the electrical work shown on the plans and specifications. Supply and install all devices required for a approved system, operating to the complete satisfaction of the contract administrator.
- The electrical contractor shall guarantee the satisfactory operation of all work and apparatus included and installed under this section of the specification for a period of 12 months after acceptance of final completion.
- Layout is to be approved by Landscape Architect prior to any construction or demolition/removals.
- Cable trenches through existing sod to be repaired with sod after backfilling.
- Install designatory lettering on all electrical equipment.
- Each Lighting unit to be controlled with a photocell mounted at pole top.

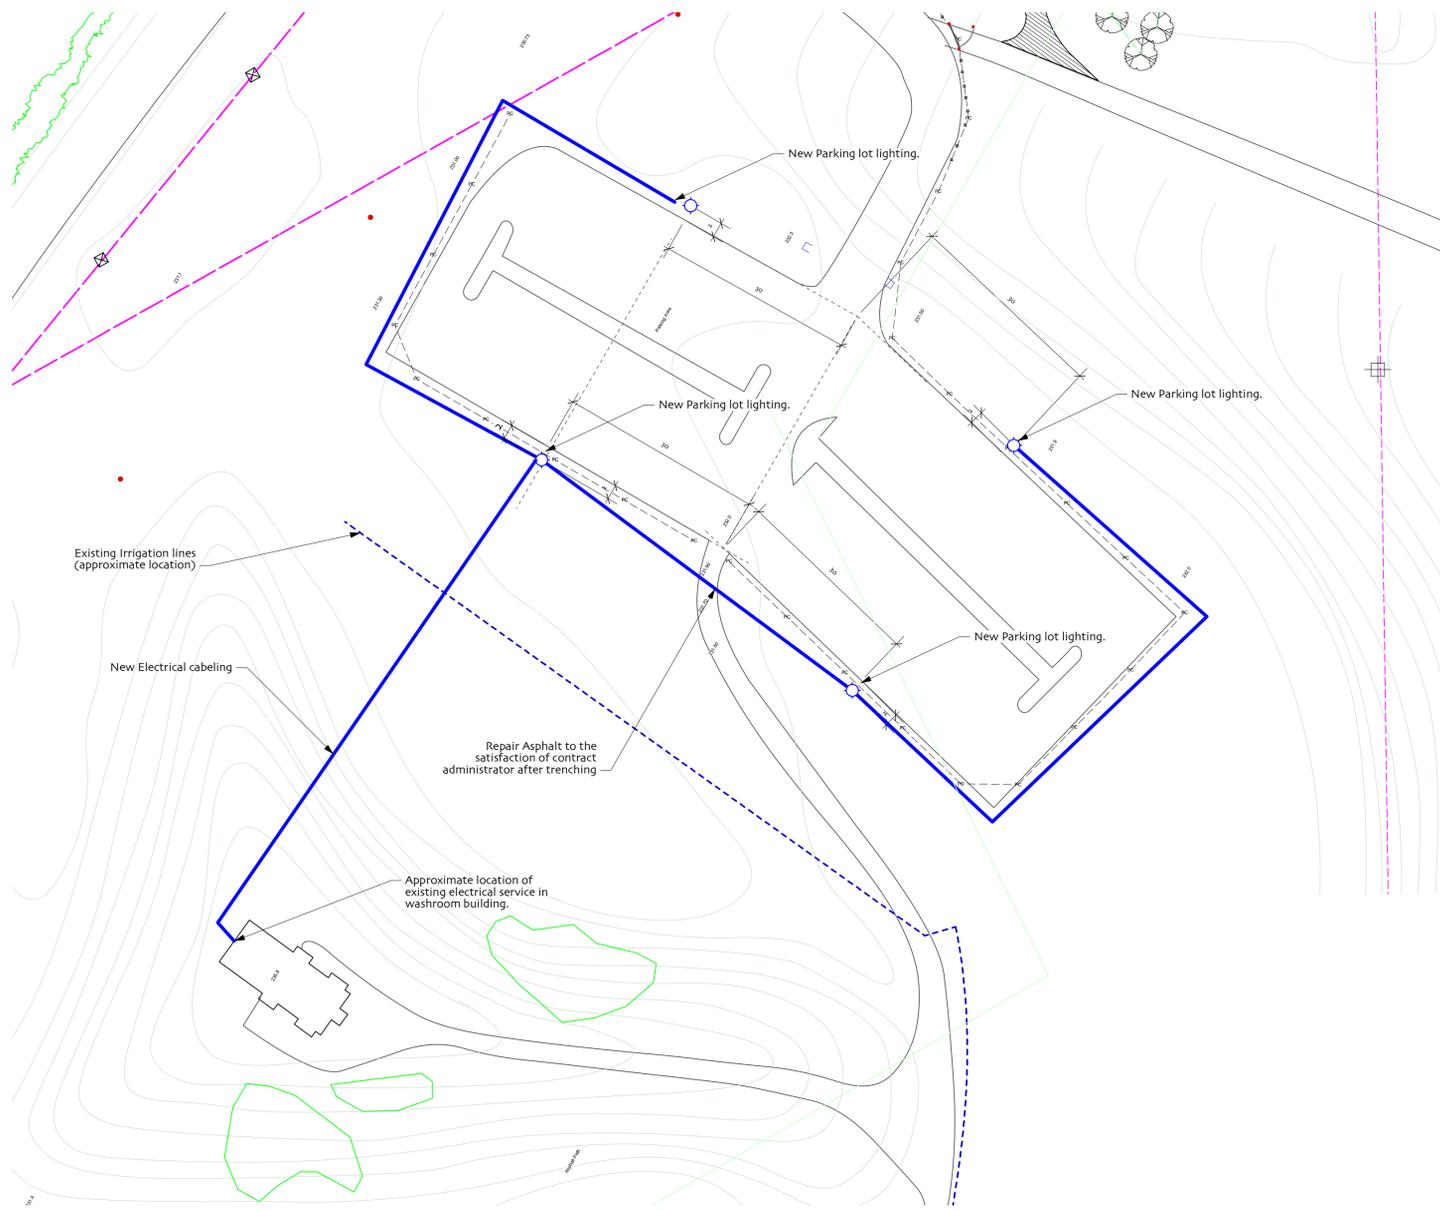

1 Electrical Plan
E-1 Scale: 1:500

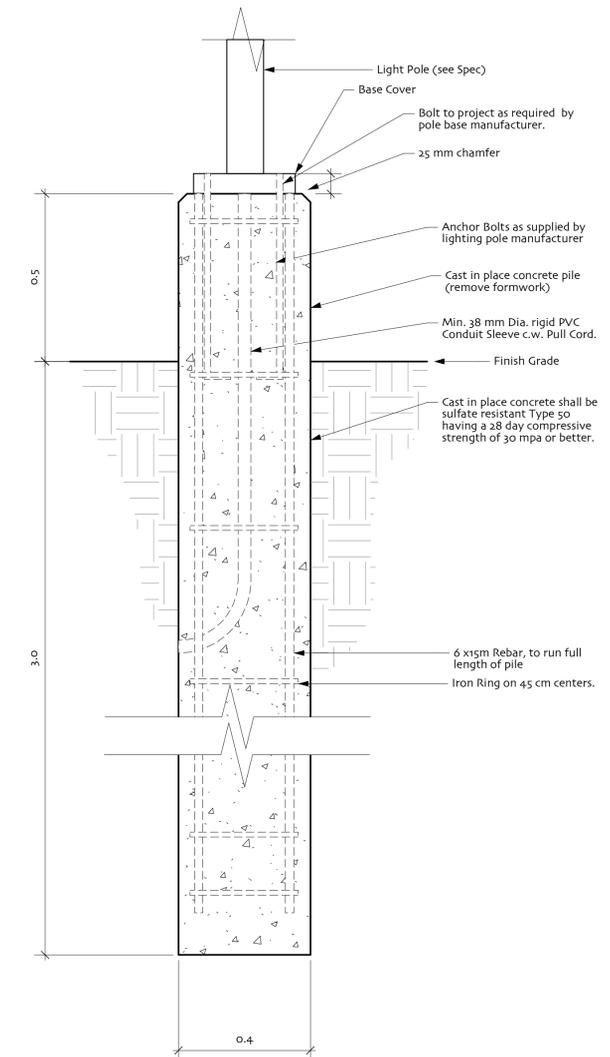

2 Light Standard Base
E-1 N.T.S.

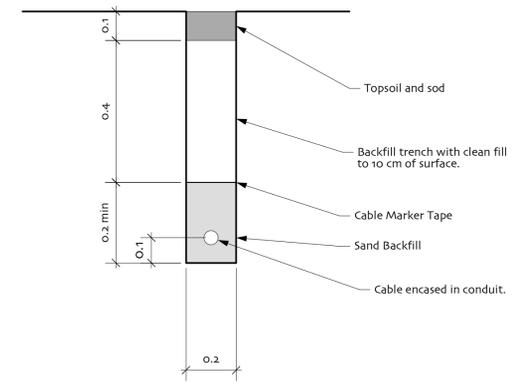

3 Cable Trench Detail
E-1 N.T.S.



- This drawing shall not be used for construction unless signed and sealed by Landscape Architect.
- Variations and modifications to the work shown will not be allowed without prior written consent of Landscape Architect.
- Drawing and Specifications, as instruments of service, are the property of the Landscape Architect. The copyright is reserved in the name of the Landscape Architect. No reproduction may be made without the prior written consent of the Landscape Architect.

MARK	DATE	DESCRIPTION
I	9/8/04	For Bid Opportunity
O	8/6/2004	For Review



PROJECT TITLE
Kilcona / HarbourView
Site Renovation

SHEET TITLE
West Parking Lot
Site Electrical