
HEET: COW-A1 (05/2005)

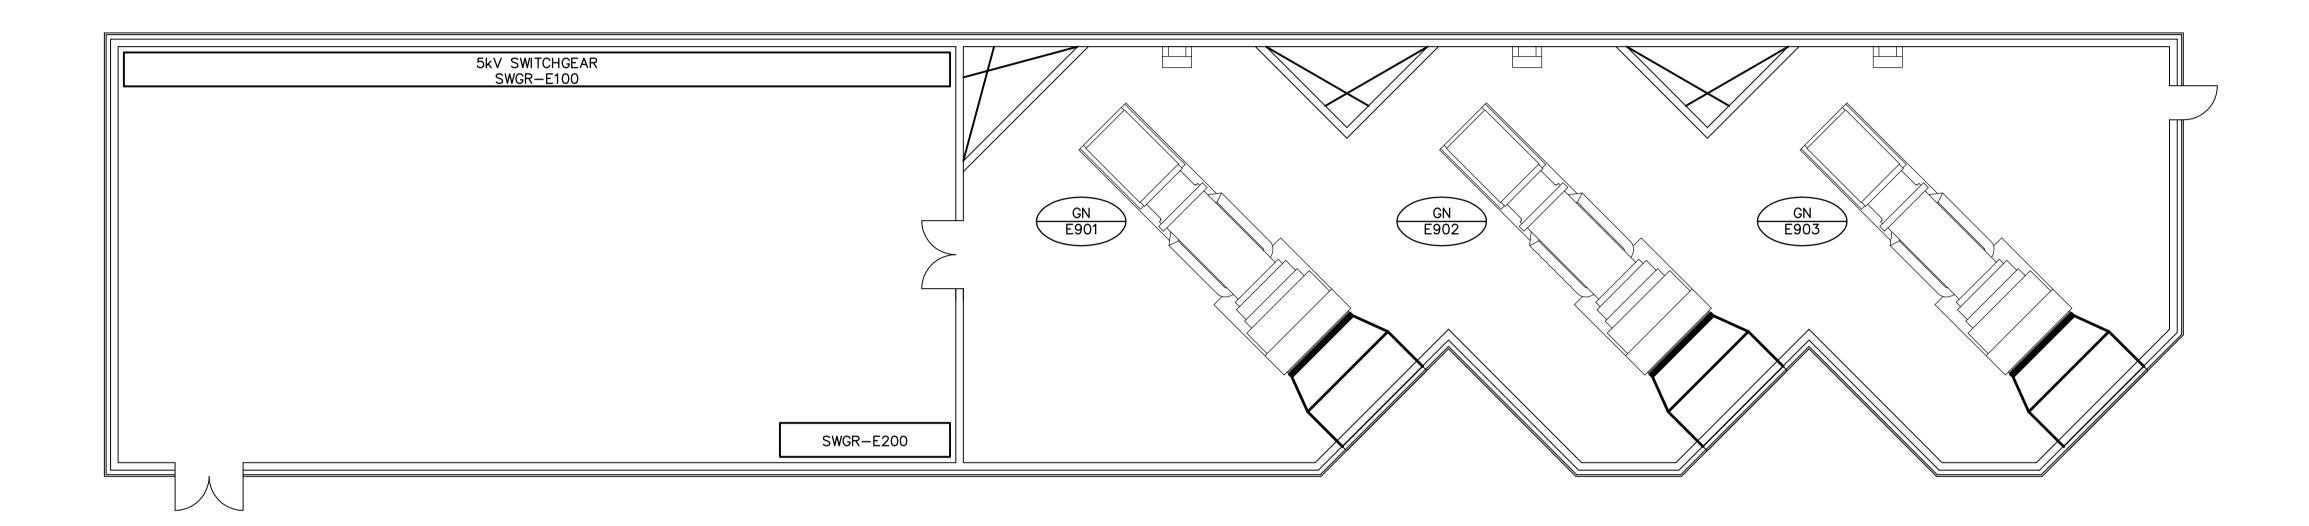

FLOOR PLAN
SCALE: 1:100

FOR INFORMATION ONLY - NOT IN CONTRACT

Certificate of Authorization Earth Tech Canada Inc.	B.M. ELEV.	Frederickson Cooper ARCHITECTS	EarthTech A Tyco International Ltd. Company	PRELIMINARY	Winnipeg THE CITY OF WINNIPEG WATER AND WASTE DEPARTMENT ENGINEERING DIVISION
No. 730 Expiry: April 30, 2006		DESIGNED BLM DRAWN BY ERC	CHECKED PS APPROVED BY	NOT FOR CONSTRUCTION	WATER TREATMENT PLANT SUPPLY OF STANDBY GENERATOR AND 5kV SWITCHGEAR CITY FILE NUMBER 05-11-29 SHEET OF
	C FOR INFORMATION ONLY 05/11/29 ERC B FOR CLIENT REVIEW 05-11-09 ERC A FOR CLIENT REVIEW 05-11-02 NO. REVISIONS DATE BY		RELEASED FOR CONSTRUCTION BY:	CONSULTANT DRAWING NO. WG-E0101	ELECTRICAL GENERATOR BUILDING FLOOR PLAN CITY DRAWING NUMBER FOR INFORMATION