
NOTES:

- 1. SEE MCC 4A & 4B SINGLE LINE DIAGRAMS AND DISTRIBUTION PANEL SCHEDULE DP-F31 FOR 600V POWER DISTRIBUTION
- 2. SEE DWG WB-E0403 FOR FILTER WIRING DETAILS

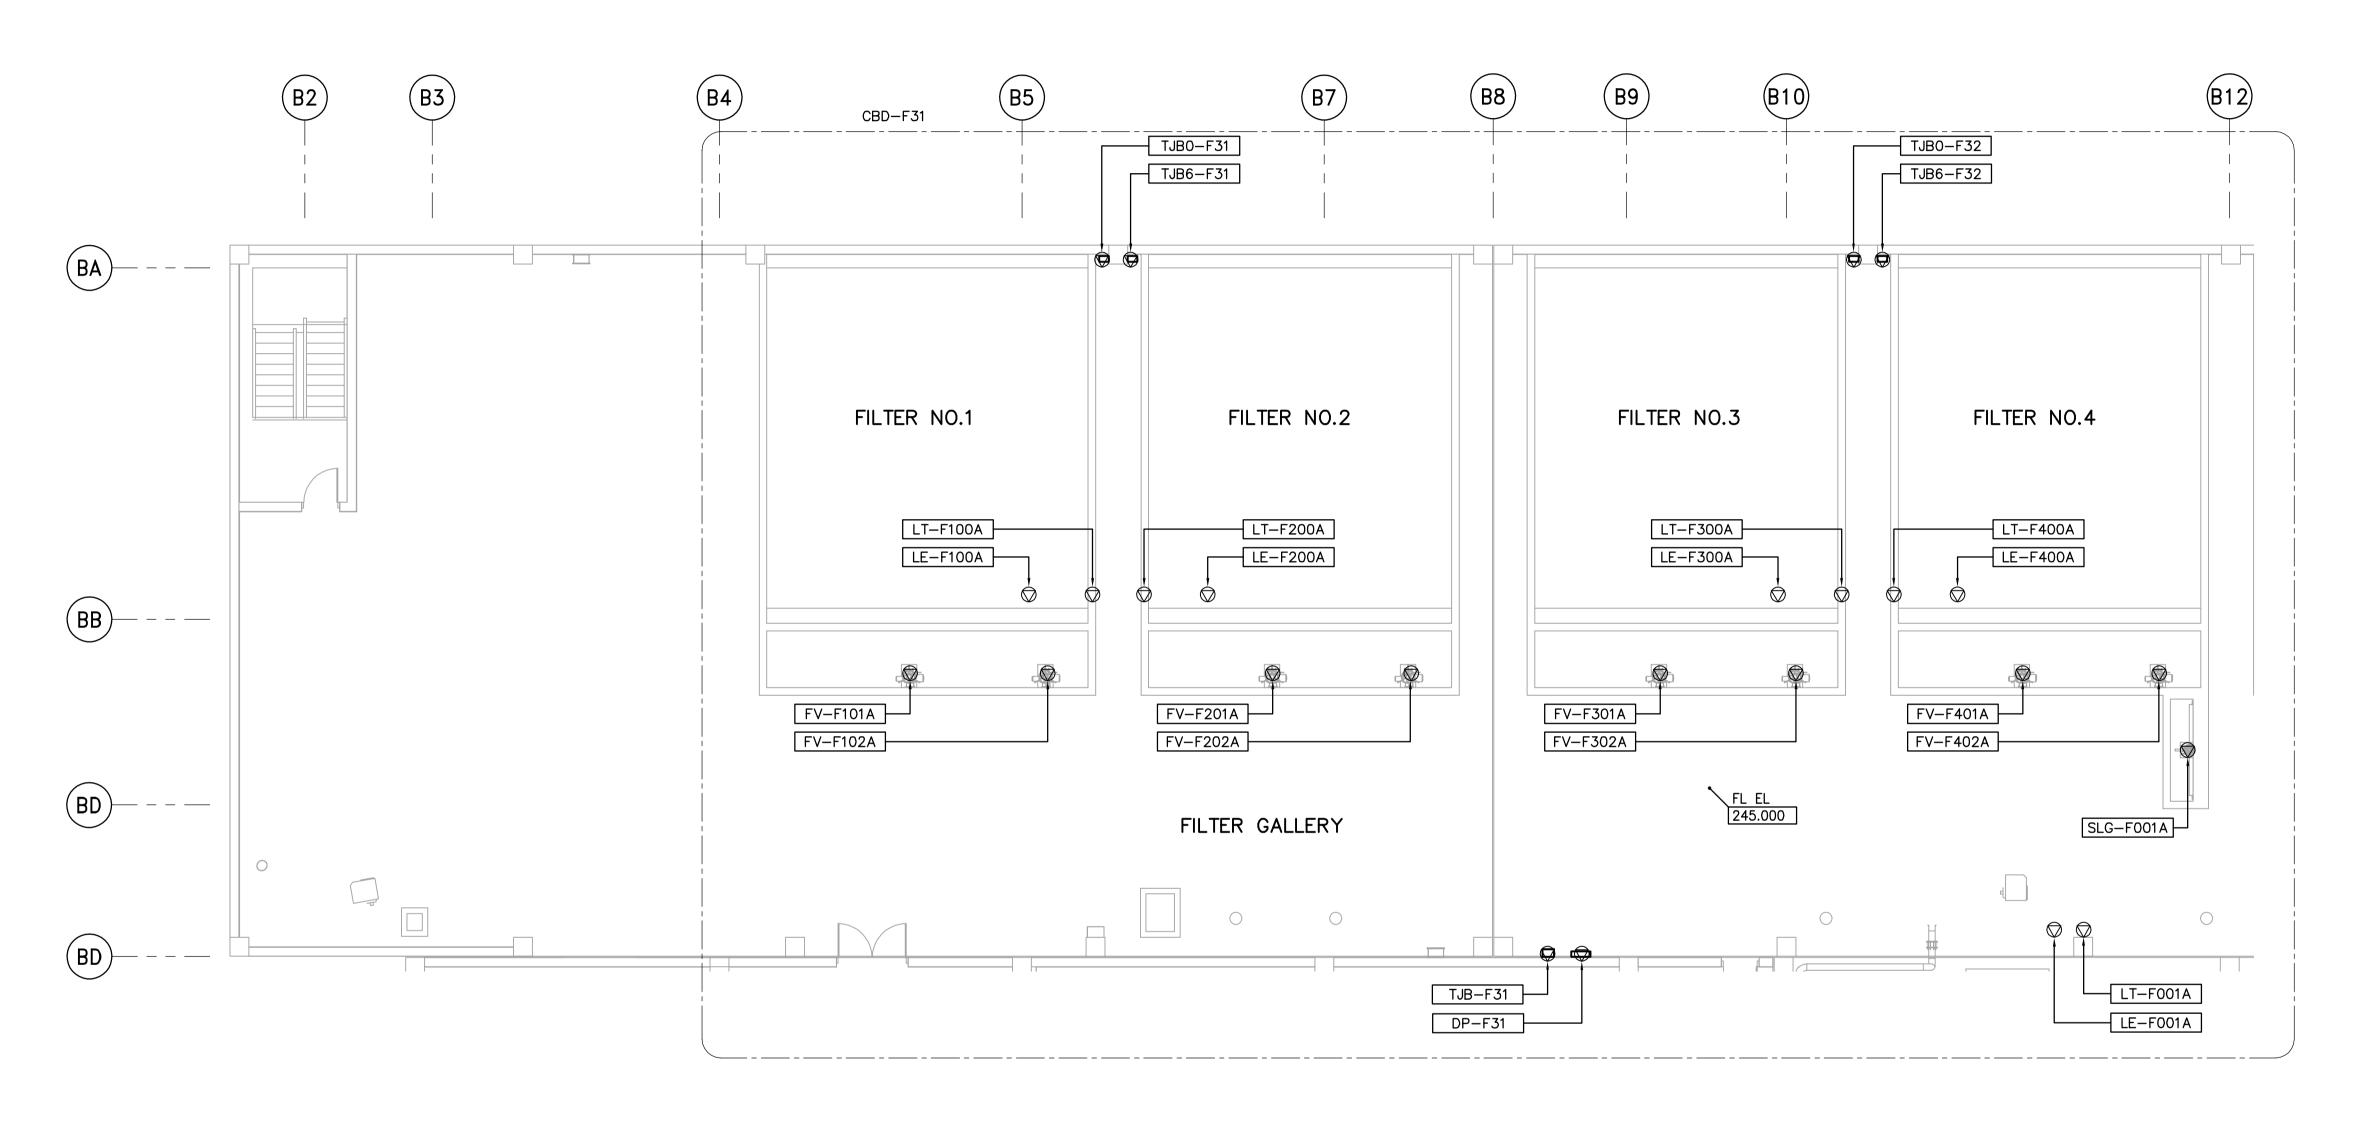

THIRD FLOOR PROCESS PLAN (AREA 1) 1:100

B.M. ELEV.

00 ISSUED FOR TENDER


NO. REVISIONS

APEGN

Certificate of Authorization

CH2M HILL Canada Ltd.

No. 1441 Expiry: April 30, 2006

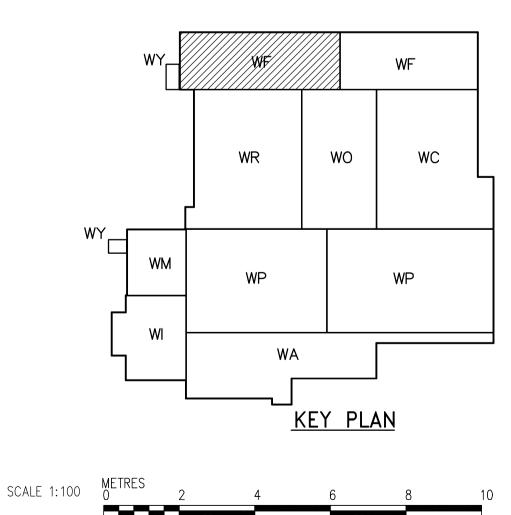

ENGINEER'S SEAL

ORIGINAL SIGNED BY

L.D. LLEWELLYN

2006/03/29

CONSULTANT DRAWING NO.

WF-E0133

EarthTech
A Tyco International Ltd. Company

AHL

R. SOROKOWSKI

DATE 2006/03/29

CHECKED BY

APPROVED BY

RELEASED FOR CONSTRUCTION BY:

CH2MHILL

Frederickson Cooper

1:100

DESIGNED

DRAWN BY

SCALE:

DATE BY DATE 2005/07/13

06/03/29 LL

THE CITY OF WINNIPEG
WATER AND WASTE DEPARTMENT
ENGINEERING DIVISION

WATER TREATMENT PLANT CITY FILE NUMBER FILTRATION MECHANICAL AND ELECTRICAL

SHEET OF CITY DRAWING NUMBER ELECTRICAL FILTRATION AREA 1 1-0601F-A-E0133-001-00D THIRD FLOOR PROCESS PLAN