
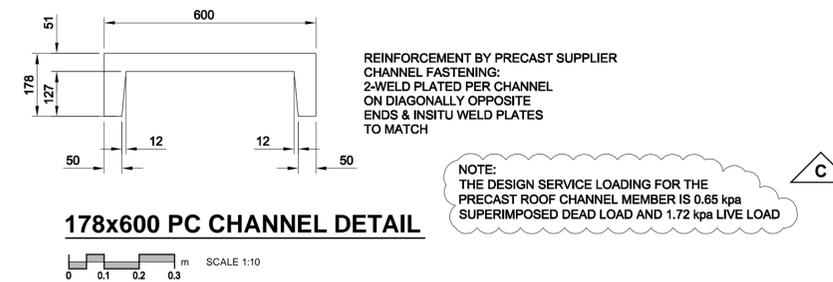
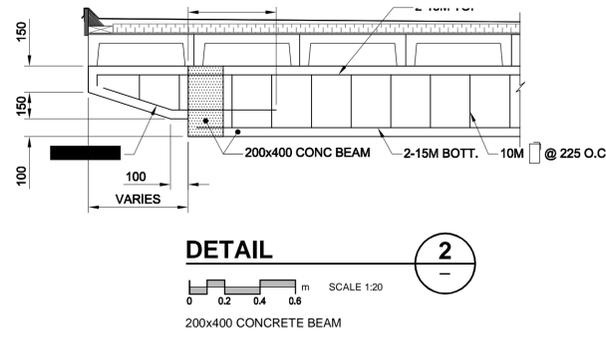
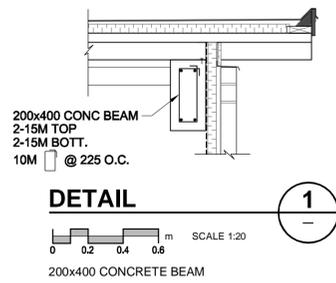
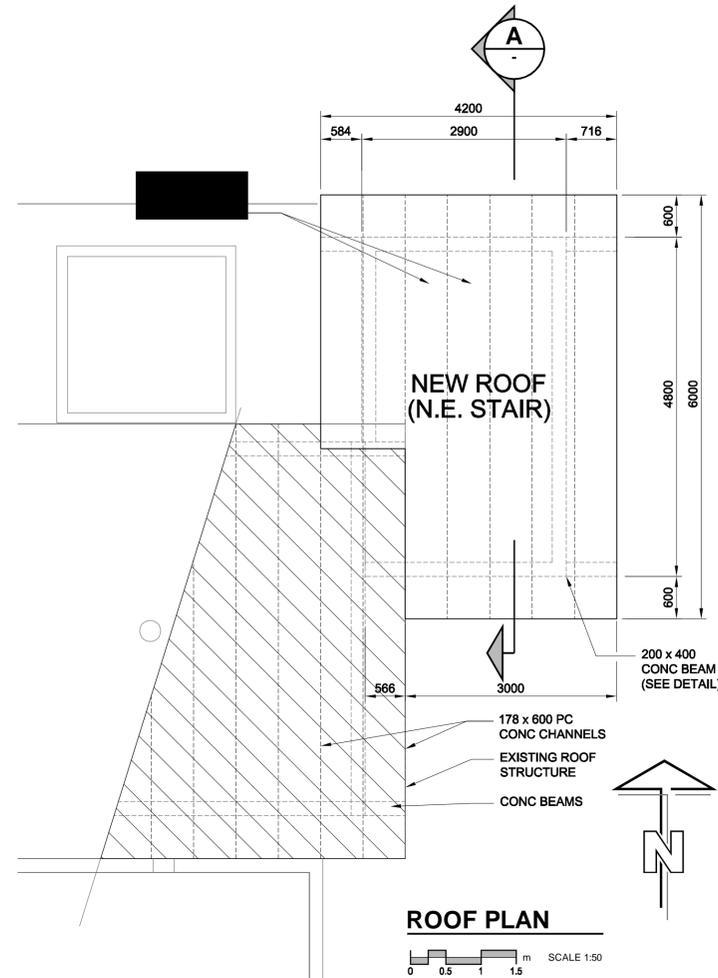


PLOT: 08/01/24 4:11:07 PM

UMA FILE NAME: D265-202-02_S-0014_RX.dwg Saved By: mpetrasanta

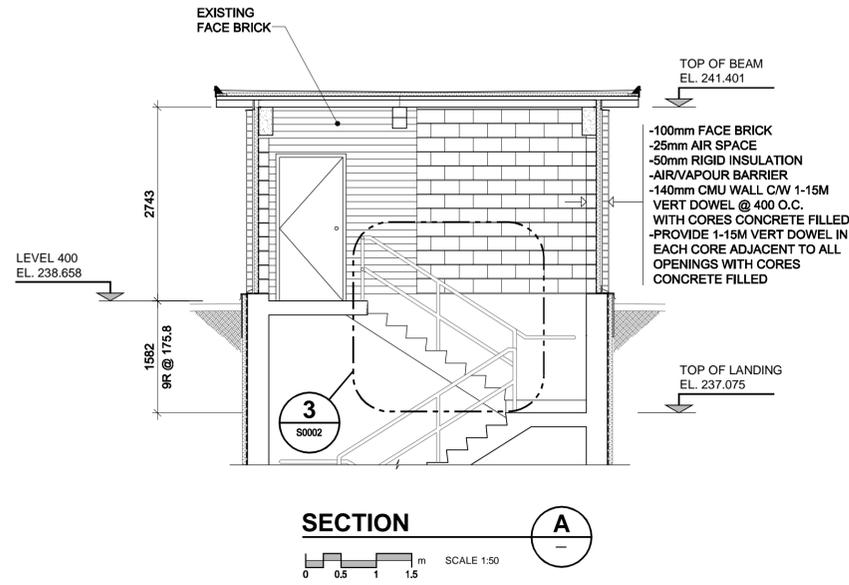

APECM
Certificate of Authorization
UMA Engineering Ltd. (MB)
No. 256 Date: 08/01/23

MP	CGC	SBB	SBB	BLL
DRN	CHK	DES	ENG	IDR
UMA REVIEW				

B.M. ELEV.	FIELD BOOK #:	UMA	AECOM
POSTED TO LBIS		DESIGNED BY: GEB	CHECKED BY: -----
		DRAWN BY: WJd	APPROVED BY: -
		HOR. SCALE AS NOTED	RELEASED FOR CONSTRUCTION
		VERTICAL AS NOTED	DATE
C	ISSUED ADDENDUM 3	08/01/23	MP
B	ISSUED FOR BID	07/12/14	LJV
A	ISSUED FOR 100% REVIEW	09/11/07	KMB
NO.	REVISIONS	DATE	BY
FILENAME: D265-202-02_S-0014_RX.dwg			

ENGINEER'S SEAL

ISSUE / REVISION C
ISSUED FOR ADDENDUM C
WAS SEALED BY
BARRY BISWANGER
AND DATED
08/01/23

THE CITY OF WINNIPEG
WATER AND WASTE DEPARTMENT

PERIMETER ROAD PUMPING STATION UPGRADES
Contract B - Building Upgrades

Structural - East Stair
ROOF PLAN, SECTIONS & DETAILS

CITY DRAWING NUMBER: **1-0111L-S009**

SHEET: **001** REV: **C** SIZE: **D**