 



D SIZE 22" x 34" (559mm x 864mm)

PLOT: 07/12/18 3:13:45 PM

UMA FILE NAME: D265-202-02\_02-S-0003\_RX.dwg Saved By: mpetrasanta

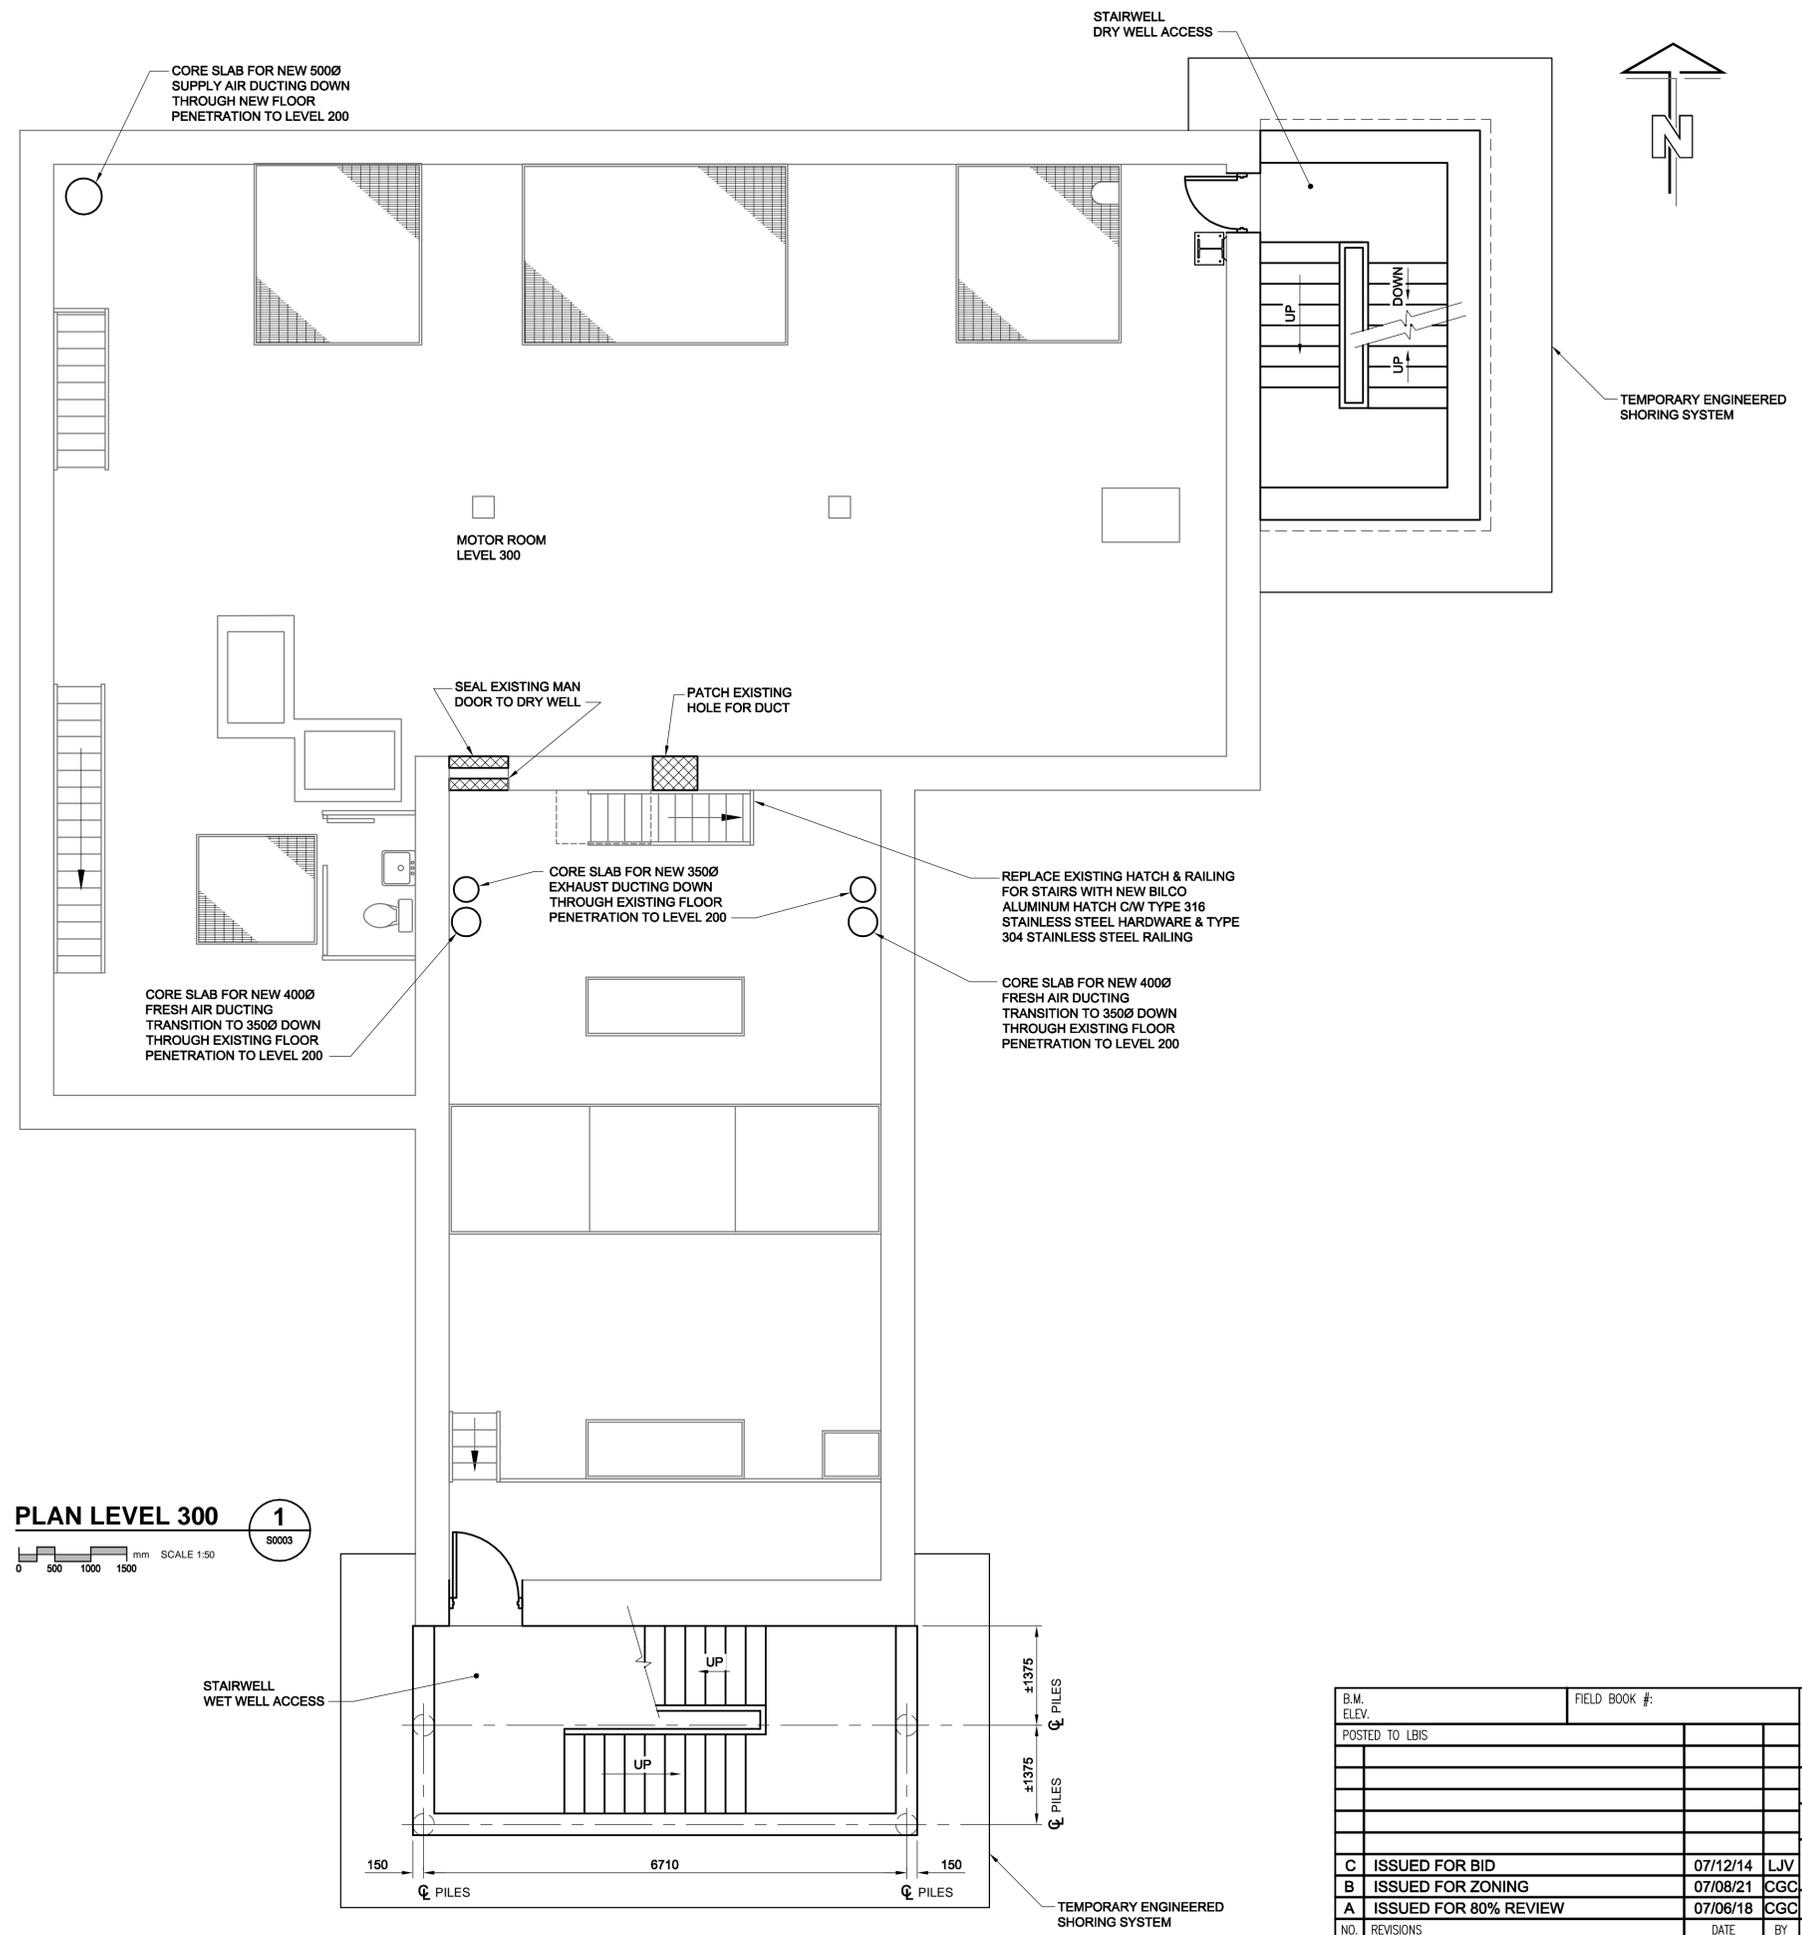

**APEGM**  
Certificate of Authorization  
UMA Engineering Ltd. (MB)  
No. 256 Date: 07/12/14

MP	CGC	SBB	SBB	BLL
DRN	CHK	DES	ENG	IDR
UMA REVIEW				

B.M. ELEV.	FIELD BOOK #:	UMA   AECOM	
POSTED TO LBIS		DESIGNED BY SBB	CHECKED BY -----
		DRAWN BY CGC	APPROVED BY -
C ISSUED FOR BID	07/12/14	LJV	HOR. SCALE AS NOTED
B ISSUED FOR ZONING	07/08/21	CGC	VERTICAL AS NOTED
A ISSUED FOR 80% REVIEW	07/06/18	CGC	DATE 07/06/14
NO. REVISIONS	DATE	BY	FILENAME: D265-202-02_02-S-0003_RX.dwg

ENGINEER'S SEAL

ISSUE / REVISION ISSUED FOR BID WAS SEALED BY BARRY BISWANGER AND DATED 07/12/14

**THE CITY OF WINNIPEG**  
WATER AND WASTE DEPARTMENT

**PERIMETER ROAD PUMPING STATION UPGRADES**  
Contract B - Building Upgrades

Structural - New Construction  
LEVEL 300 FLOOR PLAN

CITY DRAWING NUMBER	SHEET	REV.	SIZE
1-0111L-S0011	001	C	D