
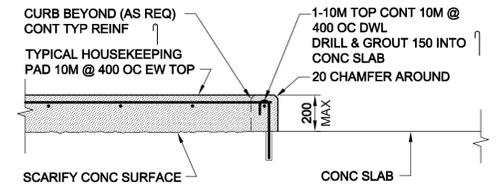
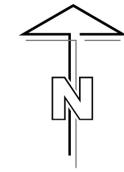


D SIZE 22" x 34" (559mm x 864mm)

PLOT: 07/12/18 3:17:02 PM


UMA FILE NAME: D265-202-02\_02-S-0004\_RX.dwg Saved By: mpetrasanta

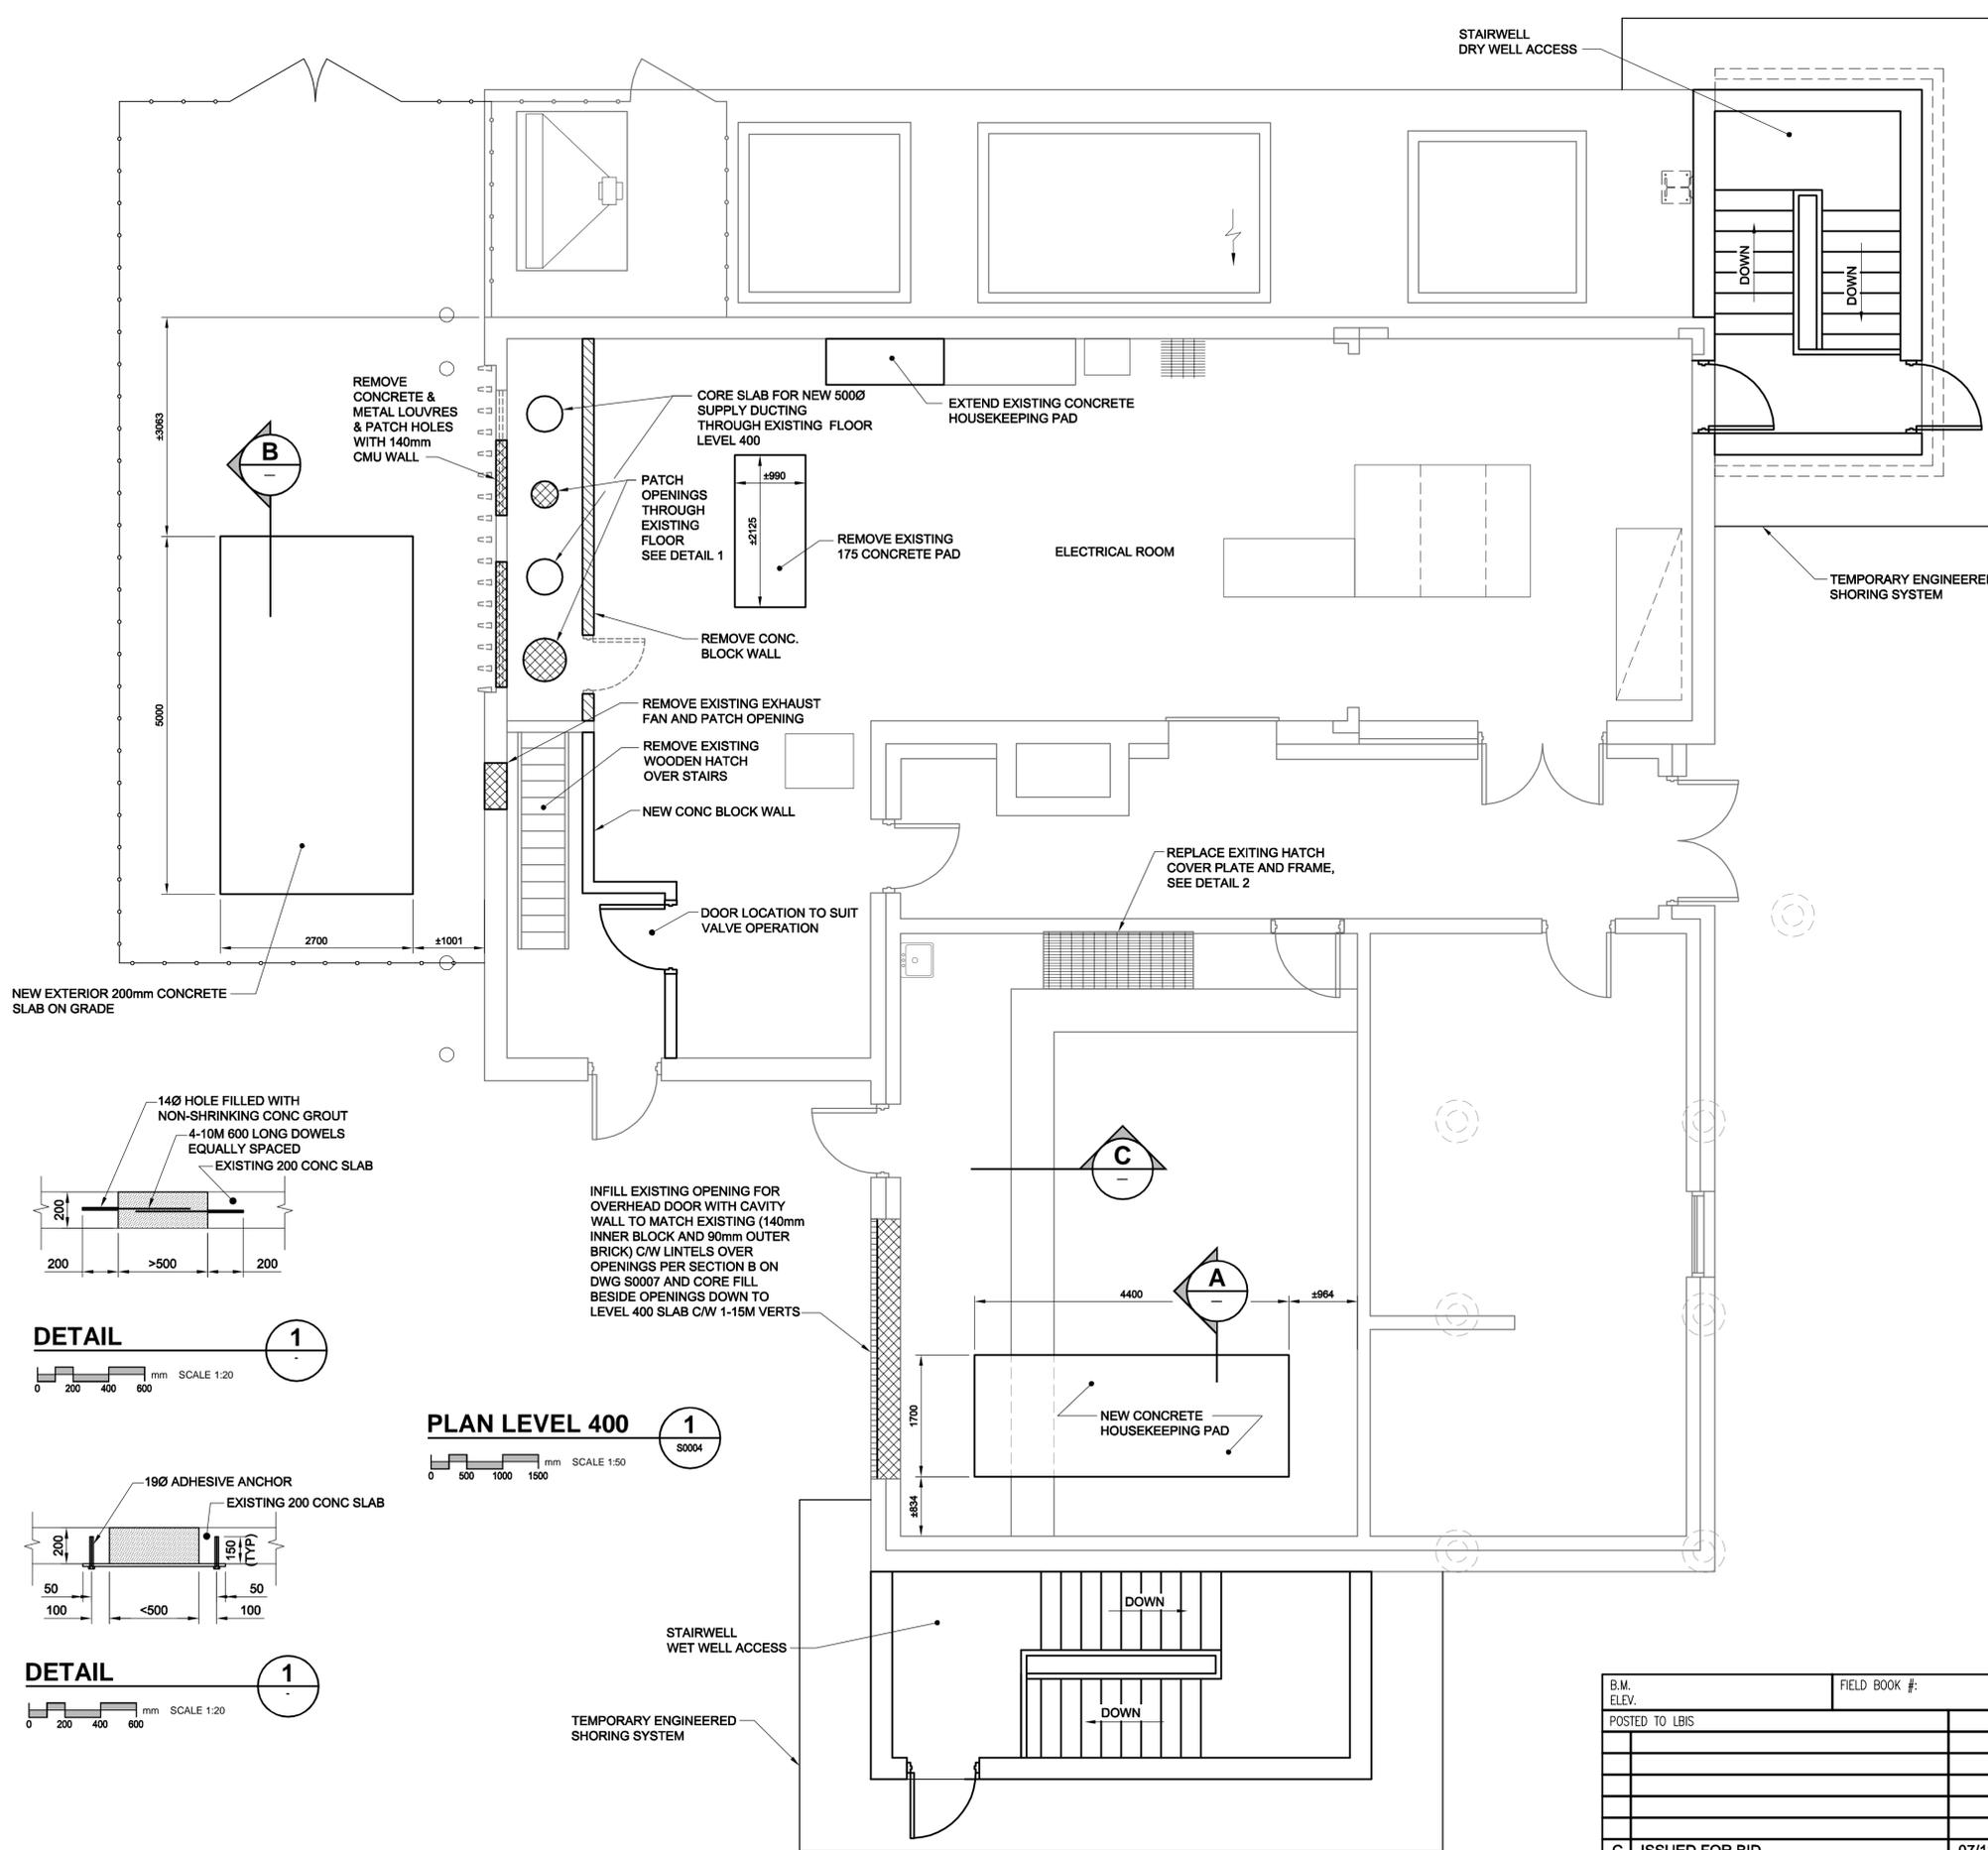


**SECTION A**




TYPICAL HOUSEKEEPING PAD

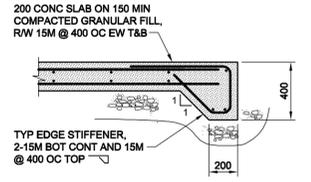



**SECTION B**

 



EXTERIOR SLAB WITH EDGE STIFFENER

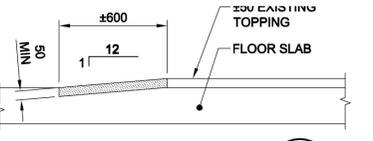


**SECTION C**

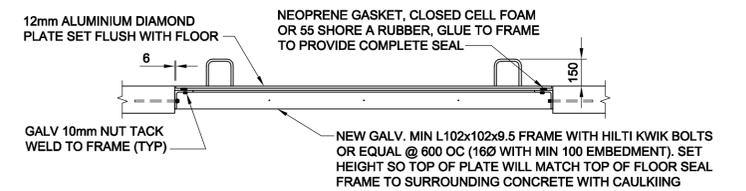 


**SECTION D**

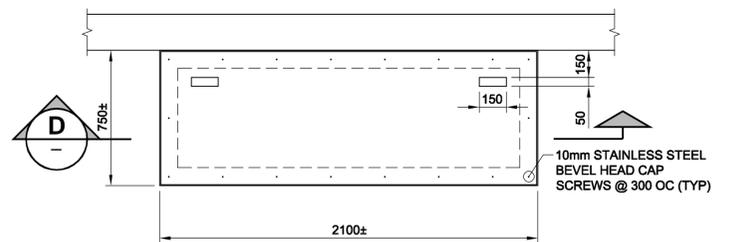 



**DETAIL 2**

 

GENERATOR ROOM L400 FLOOR PLATE DETAIL

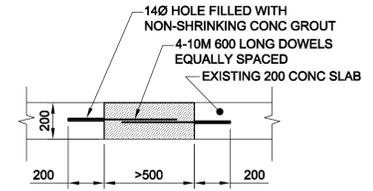

**DETAIL 1**

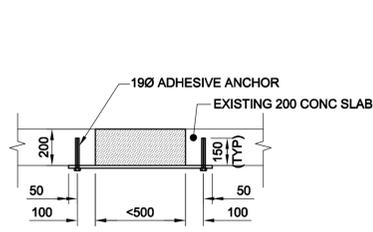 

**DETAIL 1**



**PLAN LEVEL 400**



**APEGM**  
Certificate of Authorization  
UMA Engineering Ltd. (MB)  
No. 256 Date: 07/12/14

MP	CGC	SBB	SBB	BLL
DRN	CHK	DES	ENG	IDR
UMA REVIEW				

B.M. ELEV.	FIELD BOOK #:	UMA   AECOM	
POSTED TO LBIS		DESIGNED BY	CHECKED BY
		SBB	-----
		DRAWN BY	APPROVED BY
		CGC	---
C ISSUED FOR BID	07/12/14	LJV	
B ISSUED FOR ZONING	07/08/21	CGC	
A ISSUED FOR 80% REVIEW	07/06/18	CGC	
NO. REVISIONS	DATE	BY	FILENAME: D265-202-02_02-S-0004_RX.dwg

© 2007 UMA ENGINEERING LTD. ALL RIGHTS RESERVED.	
HOR. SCALE AS NOTED	RELEASSED FOR CONSTRUCTION
VERTICAL AS NOTED	DATE
DATE 07/06/18	DATE

ENGINEER'S SEAL

ISSUE / REVISION ISSUED FOR BID WAS SEALED BY BARRY BISWANGER AND DATED 07/12/14

**THE CITY OF WINNIPEG**  
WATER AND WASTE DEPARTMENT

**PERIMETER ROAD PUMPING STATION UPGRADES**  
Contract B - Building Upgrades

Structural - New Construction  
LEVEL 400 FLOOR PLAN

CITY DRAWING NUMBER	SHEET	REV.	SIZE
1-0111L-S0012	001	C	D