




**1 PUMP HOUSE PLAN**  
Scale: 1:20

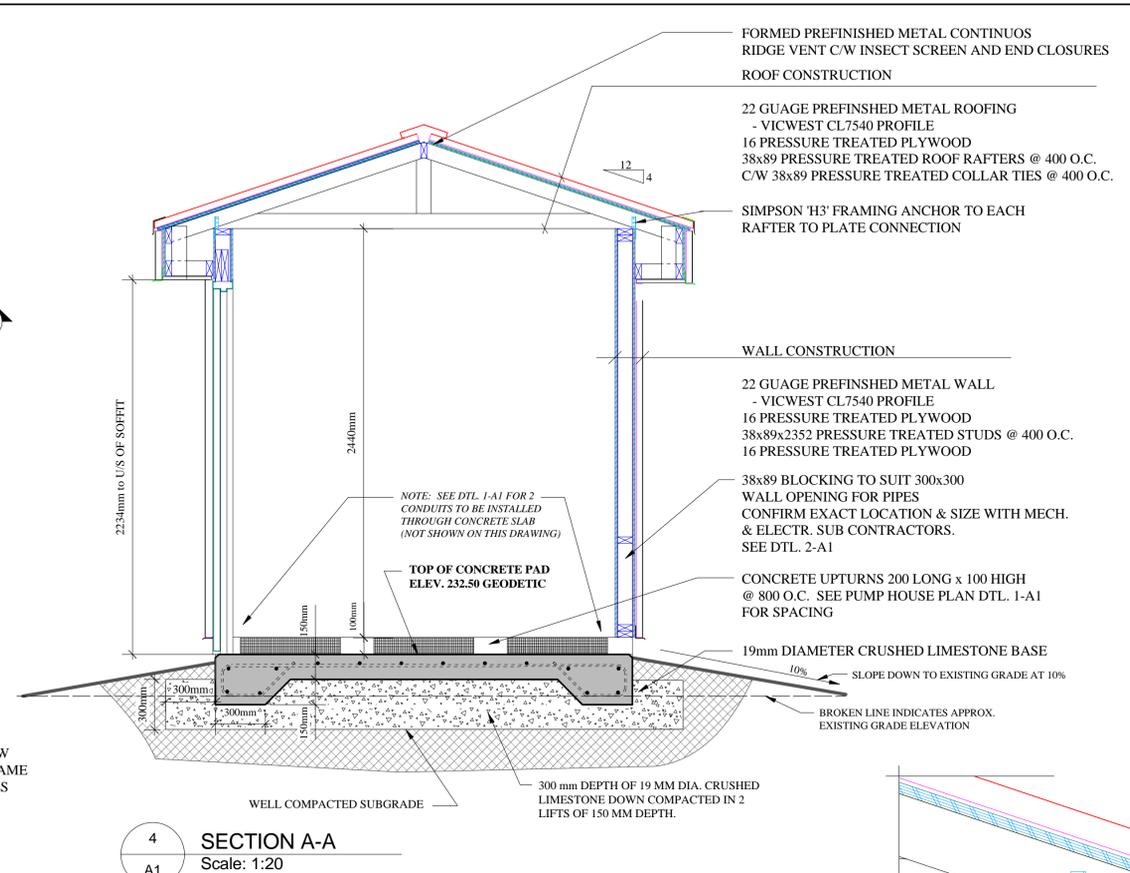


**4 SECTION A-A**  
Scale: 1:20

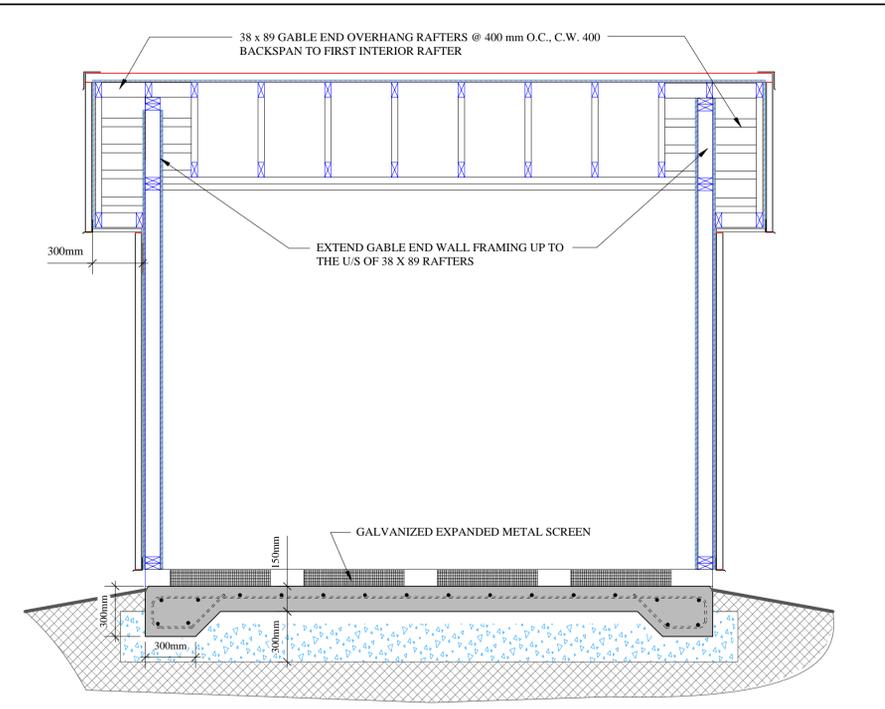


**5 SECTION B-B**  
Scale: 1:20

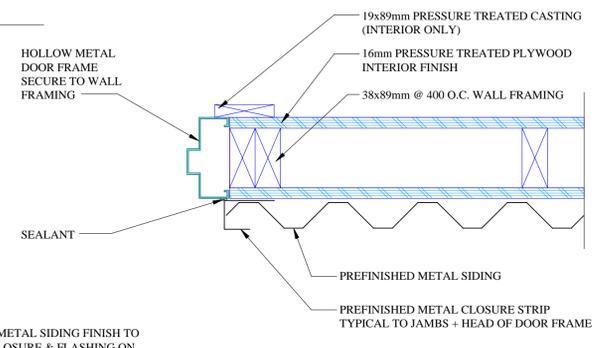


**6 WALL DETAIL**  
Scale: 1:5

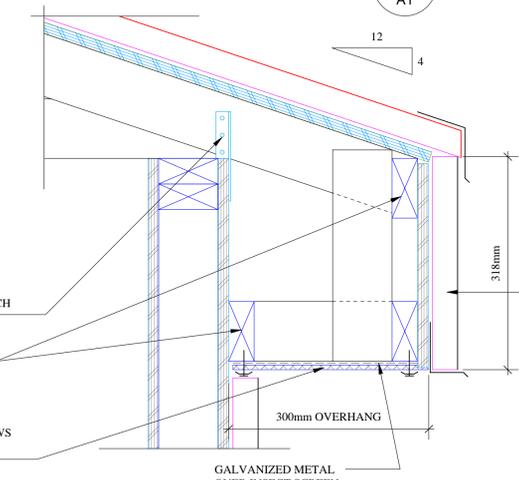


**7 SOFFIT DETAIL**  
Scale: 1:5

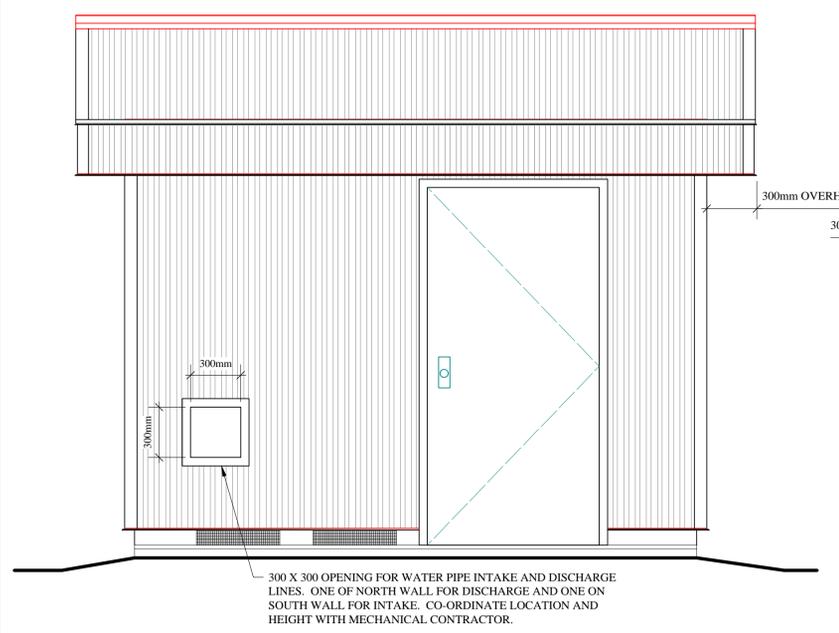

**2 PUMP HOUSE NORTH ELEVATION**  
Scale: 1:20

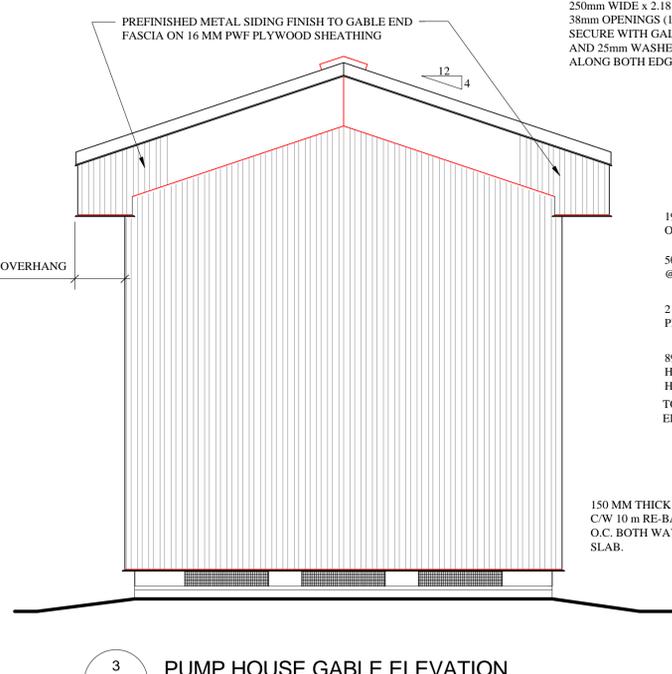

**3 PUMP HOUSE GABLE ELEVATION**  
Scale: 1:20

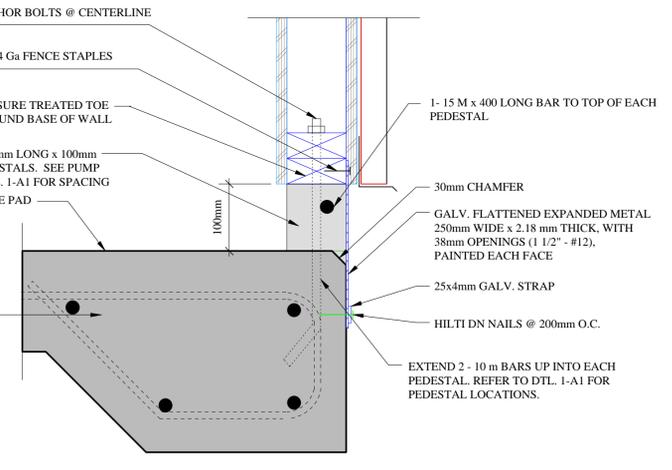

**8 THICKEN SLAB/CURB EDGE DETAIL**

**PUMPHOUSE DOOR, FRAME + HARDWARE**

**DOOR + FRAME**

914x2134mm 14GAUGE STEEL HOLLOW METAL DOOR HUNG IN A WELDED 16 GAUGE COLD FORMED STEEL FRAME C/W APPROPRIATE WALL AND SILL ANCHORS TO SUIT EXTERIOR WALL CONSTRUCTION. DOOR + FRAME TO BE MANUFACTURED FROM WIPE COATED GALVANIZED STEEL READY FOR SITE PAINTING. DOOR TO BE (R-11) POLYURETHANE FILLED CAVITY.

**HARDWARE**

HINGE: 1 1/2" PAIR FBB179 NRP. 4"x4"  
 LOCKSET: SARGENT 637 LOCKSET 'ORBIT' TRIM KEYPED TO MATCH DEADBOLT  
 DEADBOLT: SCHAGE B760 DEADBOLT  
 CHECK CHAIN: HEAVY DUTY CHECK CHAIN C/W COVER C26D

PROJECT TITLE		NO.		REVISIONS		BY		DATE	
JOHN BLUMBERG SOCCER COMPLEX									
DRAWING TITLE		DRAWN BY		SCALE		SHEET NO.			
		K.R.		AS NOTED		A1			
NEW IRRIGATION PUMPHOUSE BUILDING		PRINT DATE		DATE					
		JAN. 29/09		JAN. 29/09					
		FILE NO.		REVISION					
		08-22		0					