


1 PUMPHOUSE LOCATION AND IRRIGATION LINE PLAN  
L1 Scale: 1:1500




MECHANICAL EQUIPMENT LEGEND:

- 1 PUMP, MOTOR AND FITTINGS
- 2 CHECK VALVE
- 3 WYE STRAINER
- 4 ISOLATION VALVE
- 5 MANIFOLD PORTING & CONNECTIONS
- 6 PRESSURE /SAFETY SWITCHES & PROGRAMMABLE RELAY
- 7 PRESSURE TANKS
- 8 MASTER CONTROL VALVE & SYSTEM CONTROLLER
- 9 DISCHARGE PIPE WITH BLOWOUT


NOTE: SEE SPECIFICATION FOR MECHANICAL DATA FOR PUMPHOUSE.

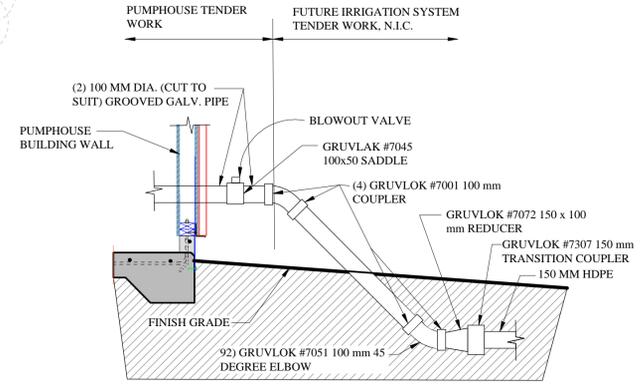

3 OUTLET PIPE SECTION  
L1 Scale: 1:20

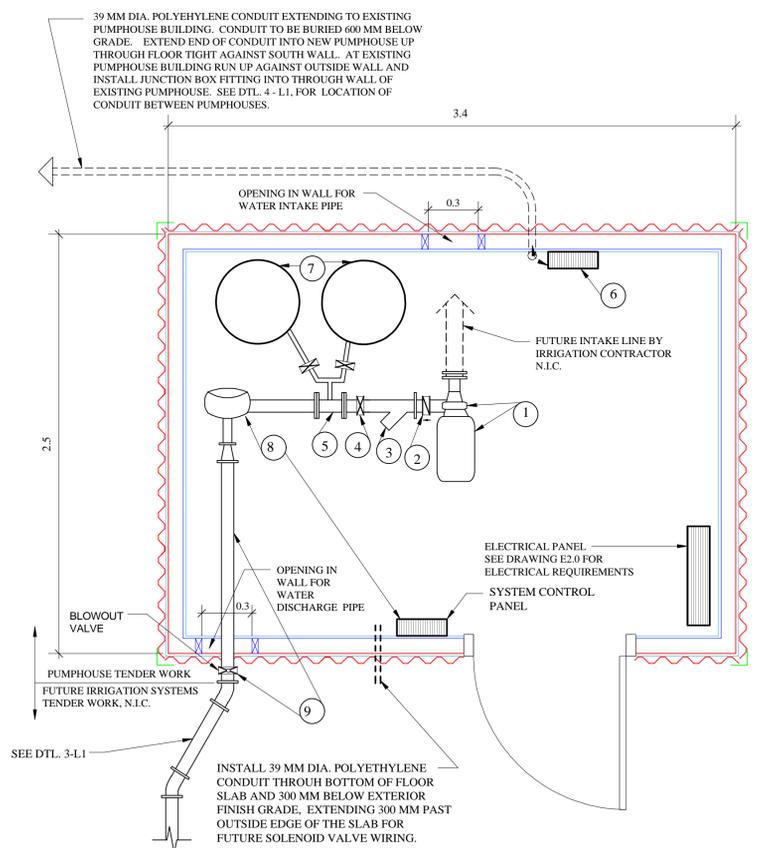

2 MECHANICAL PLAN SCHEMATIC  
L1 Scale: 1:20

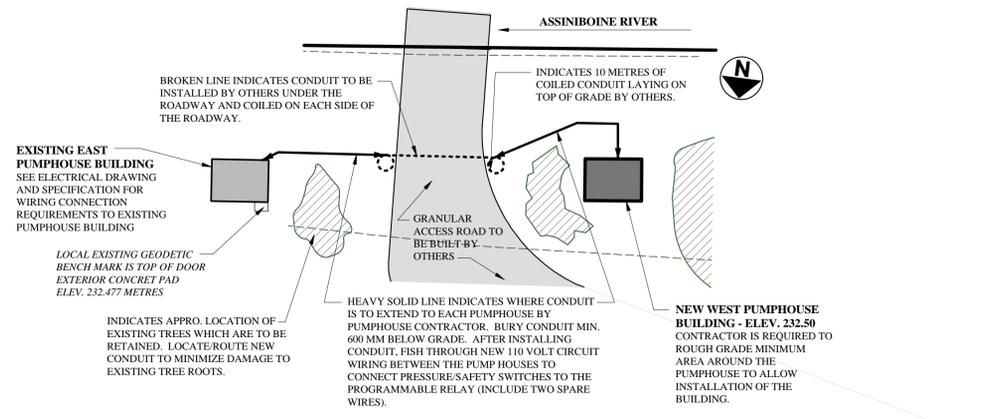

4 PUMPHOUSE LOCATION PLAN  
L1 Scale: 1:200

PROJECT TITLE		NO.	REVISIONS	BY	DATE
JOHN BLUMBERG SOCCER COMPLEX					
KEN RECH LANDSCAPE ARCHITECTS INC. 1480 Wellington Crescent Winnipeg Manitoba Fax 489-6852 R3N 0B3 Tel(204) 489-6616					
DRAWING TITLE	DRAWN BY	SCALE	AS NOTED	SHEET NO.	
NEW IRRIGATION PUMPHOUSE SITE PLAN	K.R.			L1	
	PRINT DATE	DATE	DATE		
	JAN. 29/09	JAN. 29/09			
FILE NO.	REVISION				
08-22	0				