




Certificate of Authorization


Stantec Consulting Ltd.


No. 1301 Date:_

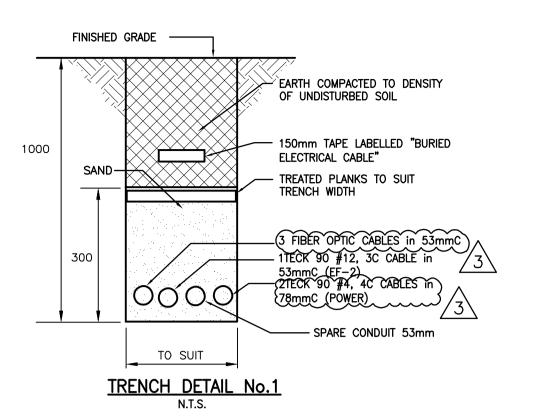


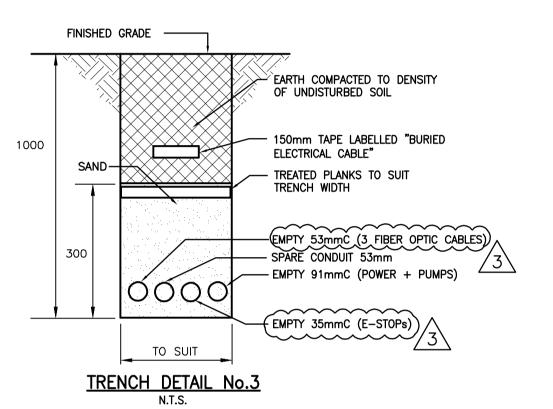

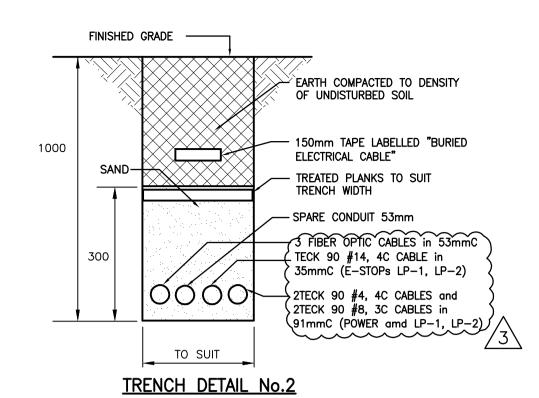

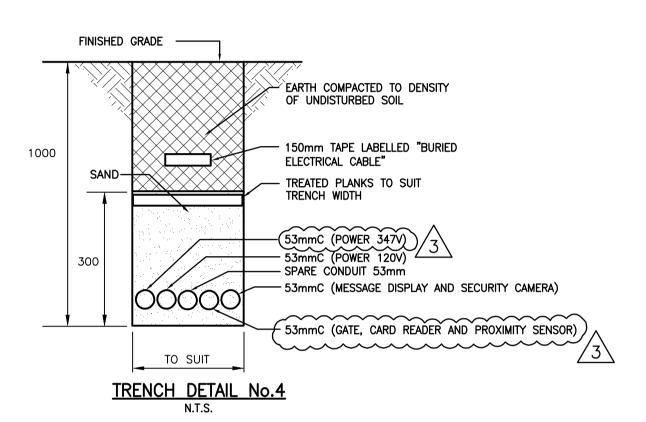

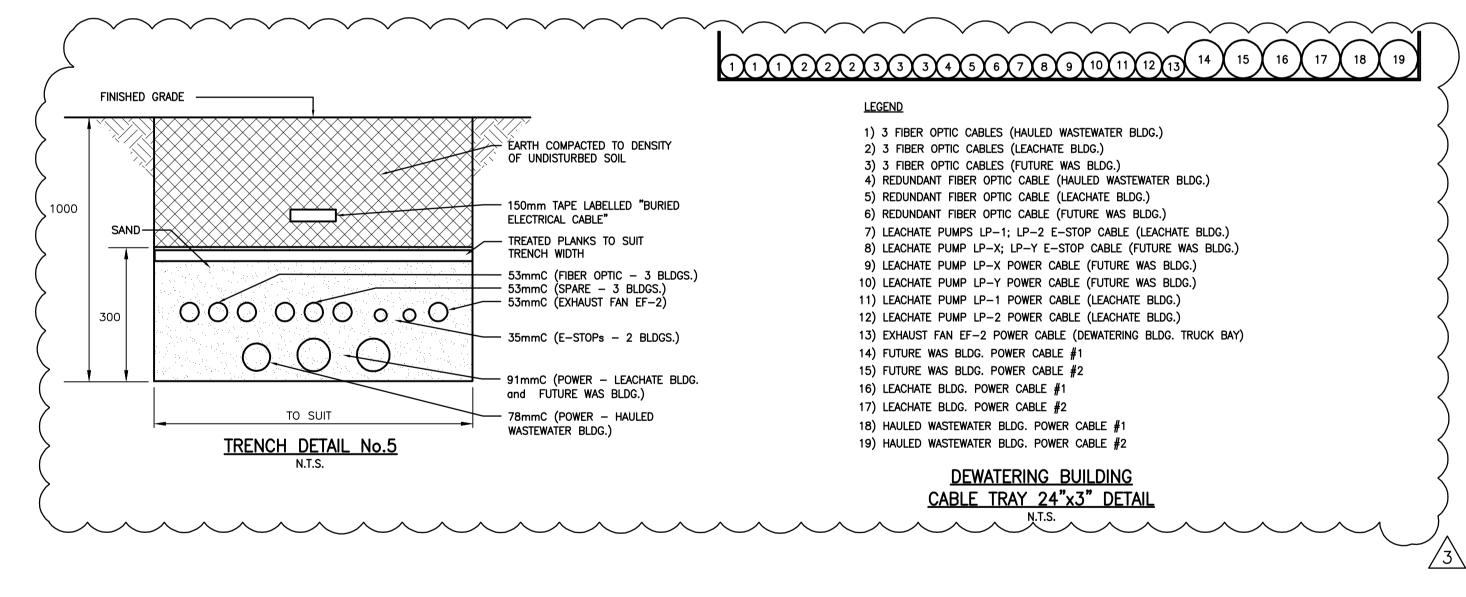

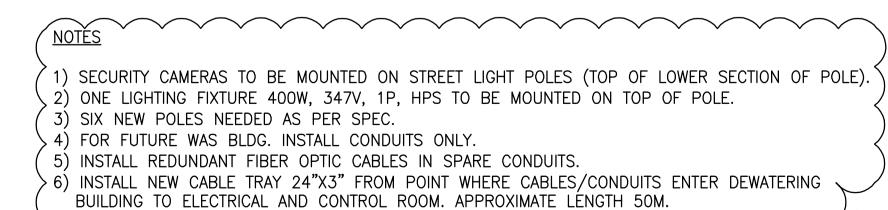

METRIC

WHOLE NUMBERS INDICATE MILLIMETRES DECIMALIZED NUMBERS INDICATE METRES

WARNING

IF POWER EQUIPMENT OR EXPLOSIVES ARE TO BE USED FOR EXCAVATION ON THIS PROJECT THE CONTRACTOR MUST: 1) NOTIFY THE GAS COMPANY OF THE PROPOSED LOCATION OF EXCAVATION. 2) TAKE PRECAUTION TO AVOID DAMAGE TO GAS COMPANY INSTALLATIONS.

SEE PROVINCIAL REGULATION 140/92 FOR DETAILS

	LOCATION APPROVED UNDERGROUND STRUCTURES	B.M. ELEV.			
	SUPV. U/G STRUCTURES DATE COMMITTEE				
	NOTE: LOCATION OF UNDERGROUND STRUCTURES AS SHOWN ARE BASED ON THE BEST INFORMATION AVAILABLE BUT NO GUARANTEE IS GIVEN THAT ALL EXISTING UTILITIES ARE SHOWN OR THAT THE GIVEN LOCATIONS ARE EXACT. CONFIRMATION OF EXISTENCE AND EXACT LOCATION OF ALL SERVICES MUST BE OBTAINED FROM THE INDIVIDUAL UTILITIES BEFORE PROCEEDING WITH CONSTRUCTION.				
		2	REVISED AS PER ADDEN		
		1	REVISED AS PER ADDEN		
		Α	ISSUED FOR TENDER		
		NO.	REVISIONS		

ROVED UCTURES	B.M. ELEV.			96	Stantec Consulting Ltd.			ENG	
DATE					Stantec	905 Waverley Street, Winnipeg, Manitobo Tel 204-489-5900 Fax 204-453-9012			
					DESIGNED BY	S.T.	CHECKED BY	D.D	
ICTURES AS ST INFORMATION IS GIVEN					DRAWN BY	S.T.	APPROVED BY		
E SHOWN OR EXACT.	2	REVISED AS PER ADDENDUM #3							1
EXACT T BE	1	REVISED AS PER ADDENDUM #2	10.03.11	S.T.	HOR. SCALE:	_	RELEASED FOR CONSTRUCTION:		
UTILITIES	Α	ISSUED FOR TENDER	10.02.16	S.T.	VERTICAL:				TEN
RUCTION.	NO.	REVISIONS	DATE	BY	DATE 09.11.20		DATE		

NGINEER'S SEAL ORIGINAL SEALED BY **SLOBODAN TREBIC** P. ENG.

10/02/16

822-2009

Winnipeg

THE CITY OF WINNIPEG WATER AND WASTE DEPARTMENT

NORTH END WATER POLLUTION CONTROL CENTRE HAULED WASTEWATER RECEIVING FACILITIES HAULED WASTEWATER AND LEACHATE RECEIVING BUILDINGS

SITE PLAN, TRENCH DETAILS

CITY DRAWING NUMBER I-0101A-E0005-001

01/000