


FIELD

PLC CONTROL PANEL

FIELD

PLC CONTROL PANEL

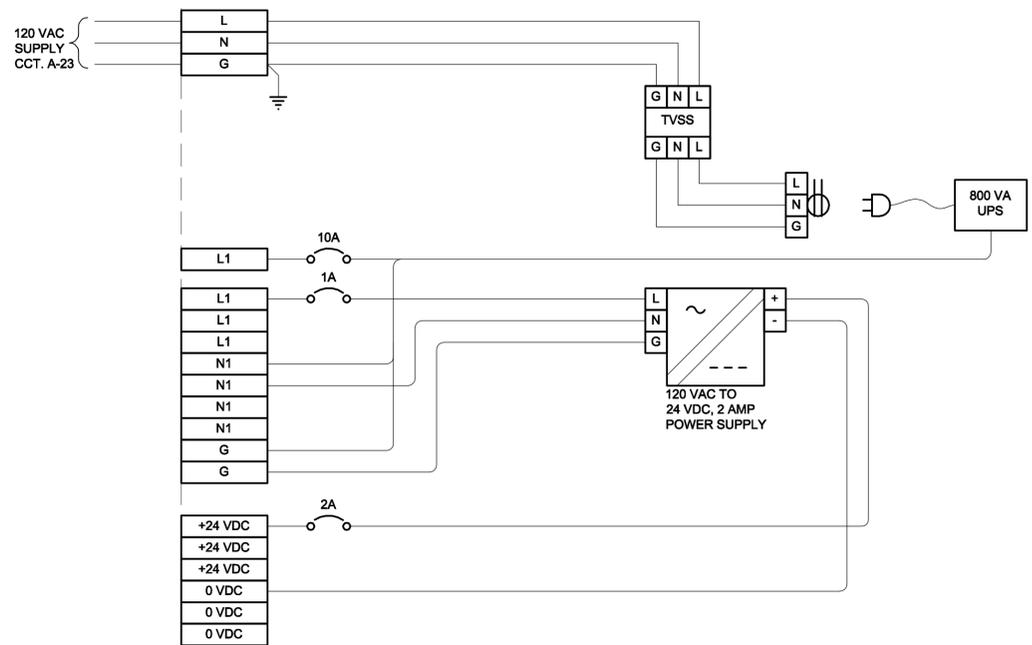

CONTROL PANEL POWER SUPPLY

SCALE: NTS

LOCATION APPROVED UNDERGROUND STRUCTURES

SUPR. U/G STRUCTURES DATE COMMITTEE
 NOTE:
 LOCATION OF UNDERGROUND STRUCTURES AS SHOWN ARE BASED ON THE BEST INFORMATION AVAILABLE. BUT NO GUARANTEE IS GIVEN THAT ALL EXISTING UTILITIES ARE SHOWN OR THAT THE GIVEN LOCATIONS ARE EXACT. CONFIRMATION OF EXISTENCE AND EXACT LOCATION OF ALL SERVICES MUST BE OBTAINED FROM THE INDIVIDUAL UTILITIES BEFORE PROCEEDING WITH CONSTRUCTION.



NO.	REVISIONS	DATE	BY
0	ISSUED FOR CONSTRUCTION	10/02/08	SCK

<p>This drawing has been prepared for the use of AECOM's client and may not be used, reproduced or relied upon by third parties, except as agreed by AECOM and its client, as required by law or for use by governmental reviewing agencies. AECOM accepts no responsibility, and denies any liability whatsoever, to any party that modifies this drawing without AECOM's express written consent. Do not scale this document. All measurements must be obtained from stated dimensions.</p>	
DESIGNED BY LCK	CHECKED BY LK
DRAWN BY SCK	APPROVED BY BTW
HOR. SCALE NONE	RELEASED FOR CONSTRUCTION KZ
VERT. SCALE -	DATE FEB. 9, 2010

PROFESSIONAL'S SEAL
 REV. 0
 ISSUED FOR CONSTRUCTION
 WAS SEALED BY
 B. L. MOORE
 AND DATED
 FEB. 8, 2010
 CONSULTANT DRAWING NO.
 D265-250-00_01-E-0005_RX.dwg

<p>THE CITY OF WINNIPEG WATER AND WASTE DEPARTMENT</p>		SHEET 27 OF 28 REV 0
<p>BRANCH I AQUEDUCT VALVE CHAMBER AT McPHILLIPS STREET PUMPING STATION</p> <p>ELECTRICAL CONTROL SCHEMATICS & LOOP DIAGRAM</p>		<p>D-11937</p>