


SYMBOL LEGEND

	SWING CHECK VALVE	M	BACK FLOW Preventer
	PRESSURE REGULATOR	\$	CONTINUATION
麦	SAFETY OR RELIEF VALVE		FLOW DIRECTION
++	HOSE BIBB VALVE	M	WATER METER
Ä	LOCK SHIELD		PUMP
	HAND WHEEL RISE STEM (OS&Y)		SCREWED UNION
14	STRAINER	<u> </u>	90 DEGREE ELBOW
\\	STRAINER	10	ELBOW UP
P	THERMOSTAT	CI	ELBOW DOWN
9	PRESSURE GAUGE]	PIPE CAP
<u></u>	CONTROL BALANCING VALVE	'_'	TEE
	GLOBE VALVE	\bowtie	GATE VALVE
ı[i	BUTTERFLY VALVE	ф	BALL VALVE

•	ROOF DRAIN
•	FLOOR DRAIN
0	HUB DRAIN
•	FLOOR DRAIN WITH TRAP
	CLEAN OUT PLUG
O -	CLEAN OUT FLOOR
V	TRAP
A.	HOT / DRAIN / COLD CONNECTIONS
	EXISTING DOMESTIC COLD WATER
	DOMESTIC COLD WATER
NOTIFICALISATION OND COD CLASSICALISATIONISATIONISATION	DOMESTIC HOT WATER
	EXISTING DOMESTIC HOT WATER DOMESTIC HOT WATER RECIRCULATION
	EXISTING DOMESTIC HOT WATER RECIRCULATION
	DOMESTIC WATER
	EXISTING DOMESTIC WATER
<i>HHHHH</i>	PIPE TO BE REMOVED
	SANITARY DRAIN ABOVE
Concention Commencential Commencential C	SANITARY DRAIN BELOW
CUED COME COME COME COME COME COME COME COME	VENT
SD	STORM DRAIN ABOVE
SD	STORM DRAIN BELOW
<u> </u>	GAS PIPING
	HEATING WATER SUPPLY
COLUMN COMMON CO	HEATING WATER RETURN
	CONDENSATE PIPING

DOUBLE L	INE DUCTWORK
	SUPPLY DUCT UP
$\boxtimes \otimes$	SUPPLY DUCT DOWN
\square	RETURN DUCT UP
	RETURN DUCT DOWN
\blacksquare	EXHAUST DUCT UP
$\boxtimes \otimes$	EXHAUST DUCT DOWN
	SQUARE SUPPLY ELBOW
D	45° RADIUS ELBOW
0	90° RADIUS ELBOW
D	45° RADIUS ROUND DUCT ELBOW
O	90° RADIUS ROUND DUCT ELBOW
- \>	AIR FLOW ARROW
	SUPPLY AIR DIFFUSER
	RETURN AIR DIFFUSER
	EXHAUST AIR DIFFUSER
力	TAKEOFF CONNECTION
*	SPIN-ON CONNECTION
	SUPPLY DUCTWORK
	RETURN DUCTWORK
*	EXHAUST DUCTWORK
	ACOUSTICALLY LINED DUCTWOR
	SQUARE DUCTWORK
	ROUND DUCTWORK
	EXISTING DUCTWORK
	DUCTWORK TO BE REMOVED
	SQUARE TO ROUND TRANSITION
A CONTRACTOR OF THE CONTRACTOR	

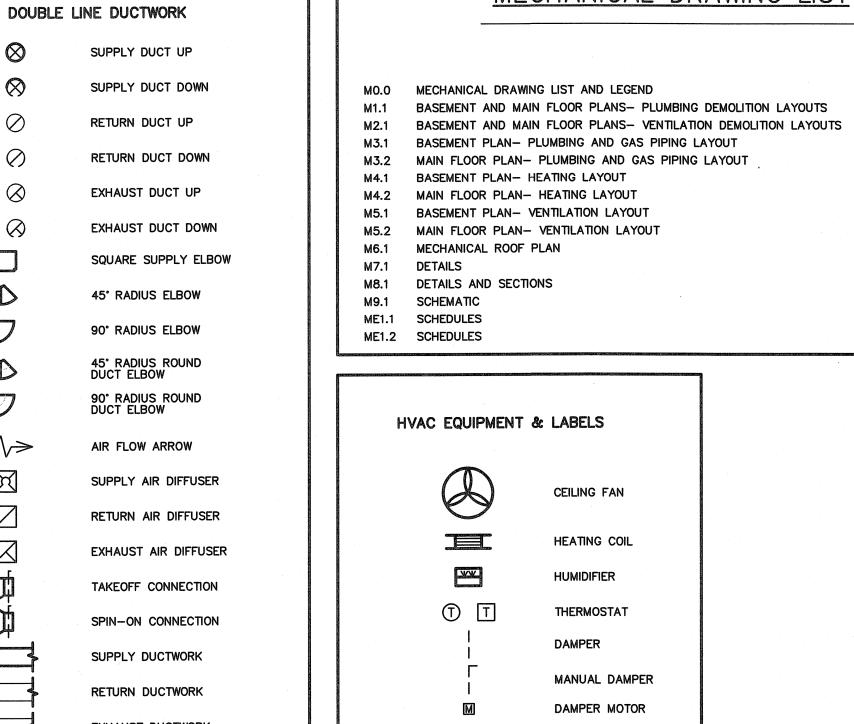

MECHANICAL DRAWING LIST

ENTRANCE HEATER

PLUMBING FIXTURE TAG

EQUIPMENT TAG

UNIT HEATER

DRAWNG SYMBOLS

QTY
TYPE
QTY
SIZE
QTY
GRILLE TAG
NECK

SCALE: NTS

SCALE: 1:100

SCALE: 1:100

SCALE: 1:100

SCALE: 1:100 SCALE: 1:100

SCALE: 1:100

SCALE: 1:100

SCALE: 1:100


SCALE: 1:100 SCALE: NTS

SCALE: NTS

SCALE: NTS

SCALE: NTS

SCALE: NTS

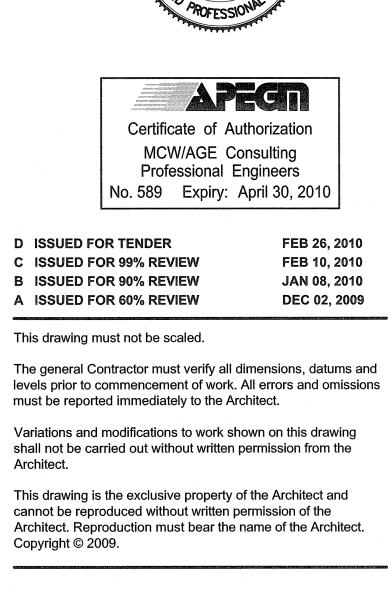



MCW / AGE Consulting Professional Engineers 210-1821 Wellington Avenue Winnipeg, Manitoba, R3H 0G4 Phone - (204) 779-7900 Fax - (204) 779-1119 E-Mail: mcw_wpg@mcw.com

FEB 26, 2010

FEB 10, 2010 **JAN 08, 2010**

DEC 02, 2009



SINCLAIR COMMUNITY CENTRE ADDITION & RENOVATIONS 490 Sinclair Street, Winnipeg

sheet title

MECHANICAL DRAWING LIST AND LEGEND

2010-02-26

project number: 5878 KLG GSR

drawing number: MO.O