


**1**  
E3.0.1 **VEHICLE WASH FLOOR PLAN - FIRE LAYOUT**  
SCALE: 1/100


**WASH BAY AND HAZARDOUS LOCATION ELECTRICAL NOTES**

- ① ALL WRING IN TRUCK BAYS TO COMPLY WITH C.E.C. 20-102. AREA FROM FINISHED FLOOR TO 50mm ABOVE FINISHED FLOOR TO BE HAZARDOUS AREA CLASS 1 ZONE 2. AREA BELOW FLOOR TO BE HAZARDOUS AREA CLASS 1 ZONE 1.
- ② ALL WRING IN WASH BAY TO BE IN COMPLIANCE WITH C.E.C. 22-002 CATEGORY 1.

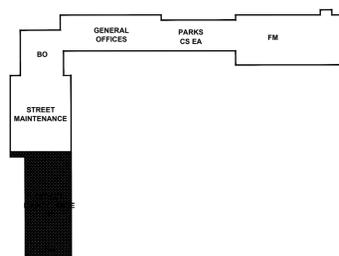

**3**  
E3.0.1 **KEY PLAN**  
SCALE: 1/2000

**2**  
E3.0.1 **STREET MAINTENANCE - FIRE LAYOUT**  
SCALE: 1/100

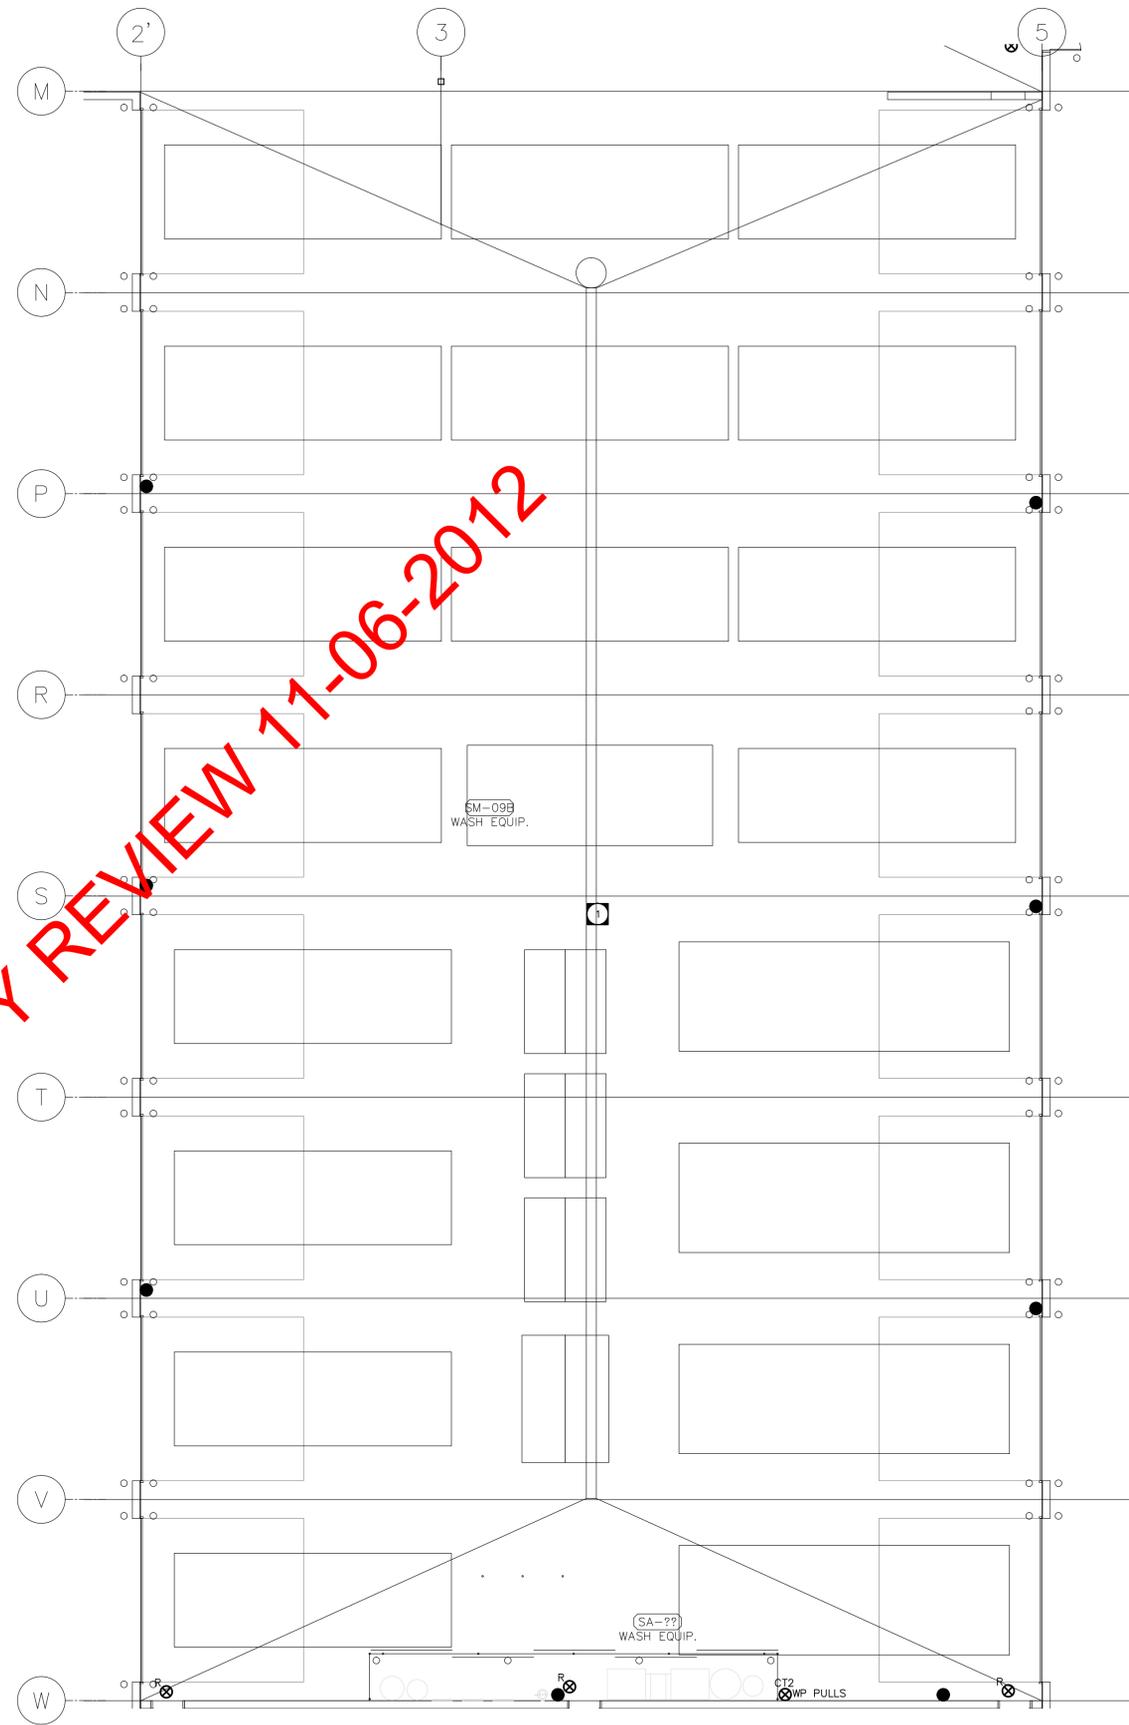

**NOT FOR CONSTRUCTION**

REV	DESCRIPTION	DATE	BY
3	ISSUED FOR 99% REVIEW	2012.06.04	MZ
2	ISSUED FOR 66% REVIEW	2012.03.06	MZ
1	ISSUED FOR 33% REVIEW	2012.01.06	MZ



**NOVA 3 ENGINEERING LTD.**  
CONSULTING ENGINEERS  
201-120 FORT STREET TEL: (204) 943-8142  
WINNIPEG, MANITOBA FAX: (204) 942-1276  
R3C 1C7 JN: 31-173  
THIS DRAWING IS THE EXCLUSIVE PROPERTY OF NOVA 3 ENGINEERING LTD. AND MAY ONLY BE REPRODUCED WITH THE WRITTEN PERMISSION OF NOVA 3 ENGINEERING LTD.  
THE CONCEPT AND DESIGN INCORPORATED INTO THIS DRAWING ARE BASED ON INFORMATION PROVIDED BY THE CLIENT AND OTHER RELATED SOURCES. PROFESSIONAL ENGINEER ACCEPTS NO RESPONSIBILITY FOR DRAWING AND DESIGN UNLESS DRAWING IS ACCOMPANIED BY ORIGINAL SEALED AND SIGNED LETTER OF INTENT AND CERTIFICATE OF INSPECTION. REFER TO WWW.NOVA3.CA FOR CAUTIONARY NOTES.



3 TERRACON PLACE  
WINNIPEG, CANADA R2J 4B3  
TEL. (204) 233 7881  
FAX (204) 233 4733  
general@ehansch.com  
www.ehansch.com

CLIENT: CITY OF WINNIPEG  
PUBLIC WORKS DEPARTMENT  
PROJECT NUMBER: 31-178E  
DRAWN BY: KC  
DATE: MARCH 06, 2012  
SCALE: AS SHOWN

PROJECT TITLE:  
CITY OF WINNIPEG  
PUBLIC WORKS EAST YARD COMPLEX  
MAIN OFFICE & GARAGES  
SHEET TITLE:  
**MAIN FLOOR FIRE LAYOUT**

SHEET NUMBER:

**E3.0.1**

REVISION NUMBER:

0