


M&R BUILDING PLAN

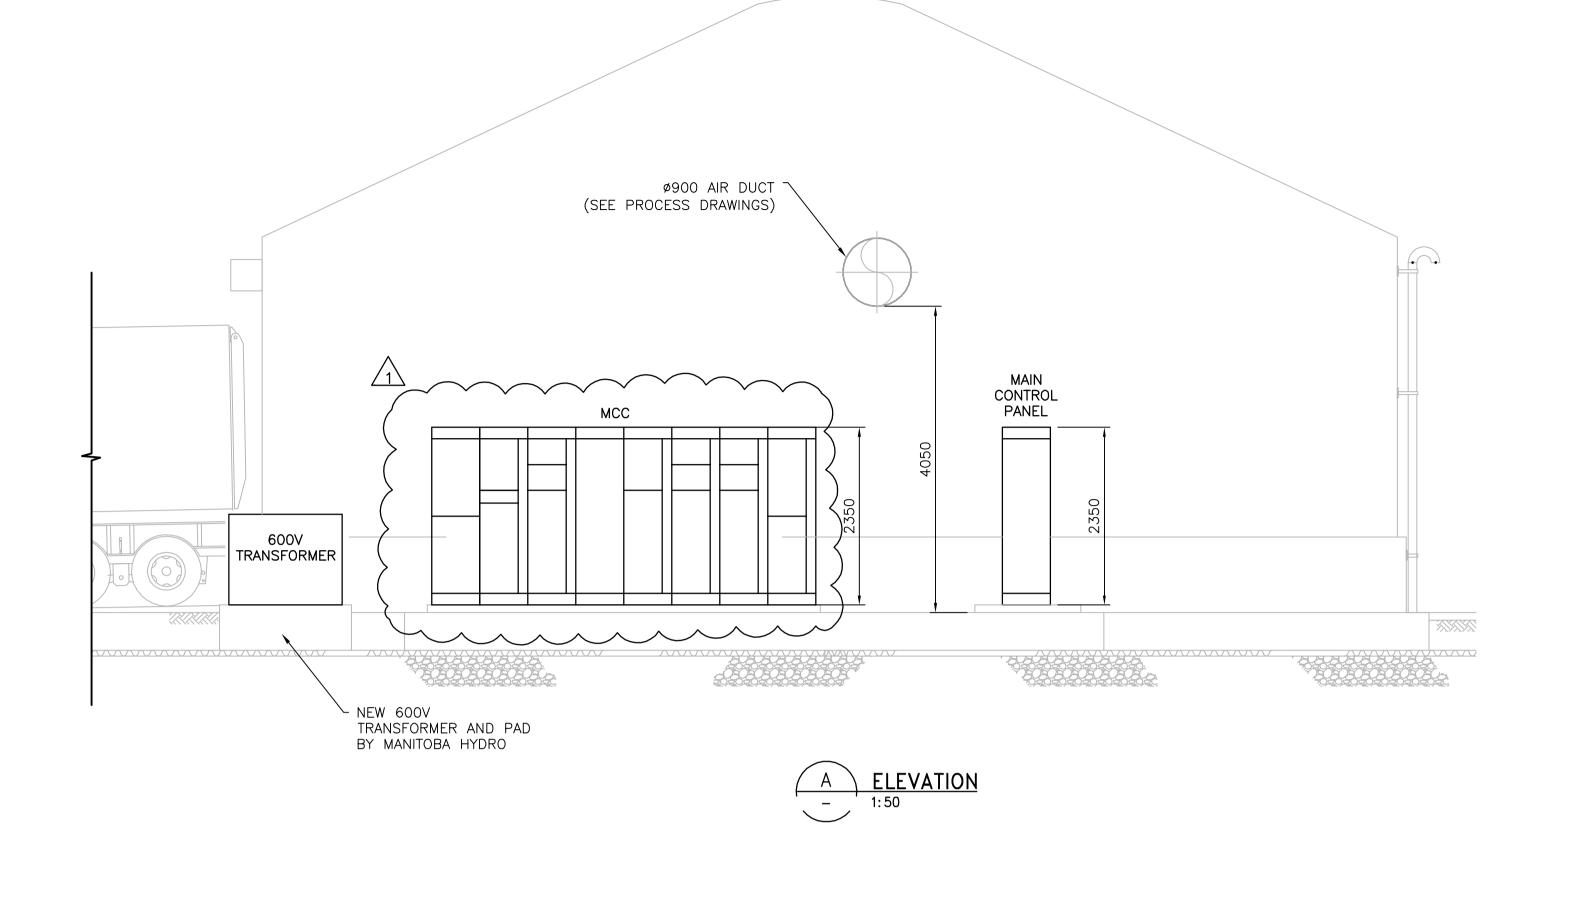

1. FOR LUMINAIRE SCHEDULE, SEE DRAWING E-203. 2. CONTRACTOR TO COORDINATE WITH EQUIPMENT

SUPPLIER TO LOCATE ELECTRICAL POWER SUPPLY FOR THE MIXER AND CONVEYORS.

B.M. ELEV.		ENGINEER'S SEAL	THE CITY OF W	INNIPEG
CONSTRUCTION COMPLETION DATE: YYYY MM DD  CH2NHLL®		ORIGINAL SIGNED BY	Winnipeg Water and Waste Department Engineering Division	
	DESIGNED BY LL CHECKED BY WT	L.D. LLEWELLYN		SHEET <b>40</b> OF <b>45</b>
	DRAWN EA APPROVED BY BW	13/01/25	LEAF AND YARD WASTE AND PILOT BIOSOLIDS COMPOSTING	CITY DRAWING NUMBER
	SCALE: RELEASED FOR CONSTRUCTION			
1 ISSUED FOR ADDENDUM 2 13/02/26 JBC	HORIZONTAL AS NOTED CONSTRUCTION	CONSULTANT DRAWING NUMBER	ELECTRICAL	1-0400B-E0003-001-01
0 ISSUED FOR CONSTRUCTION 13/01/25 JBC	VERTICAL	E-202	M&R BUILDING LIGHTING PLAN	
NO. REVISIONS DATE BY	DATE 2013 01 25 DATE	L-202	WICK BUILDING LIGHTING PLAN	
	PLOT DATE: 2013 02 26		FILE PATH: C:\pw_workdir\ch2mhill_wbg\jcortez1\d0198672\	

FILE PATH: C:\pw\_workdir\ch2mhill\_wbg\jcortez1\d0198672\ FILE NAME: E-202\_438634.dwg BID OPPORTUNITY: 839-2012