

 


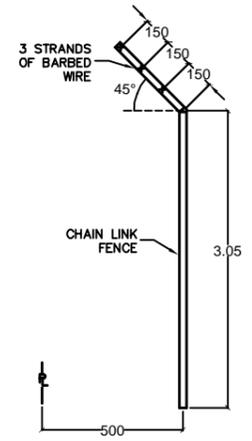

FOR CONTINUATION SEE DWG D-12963

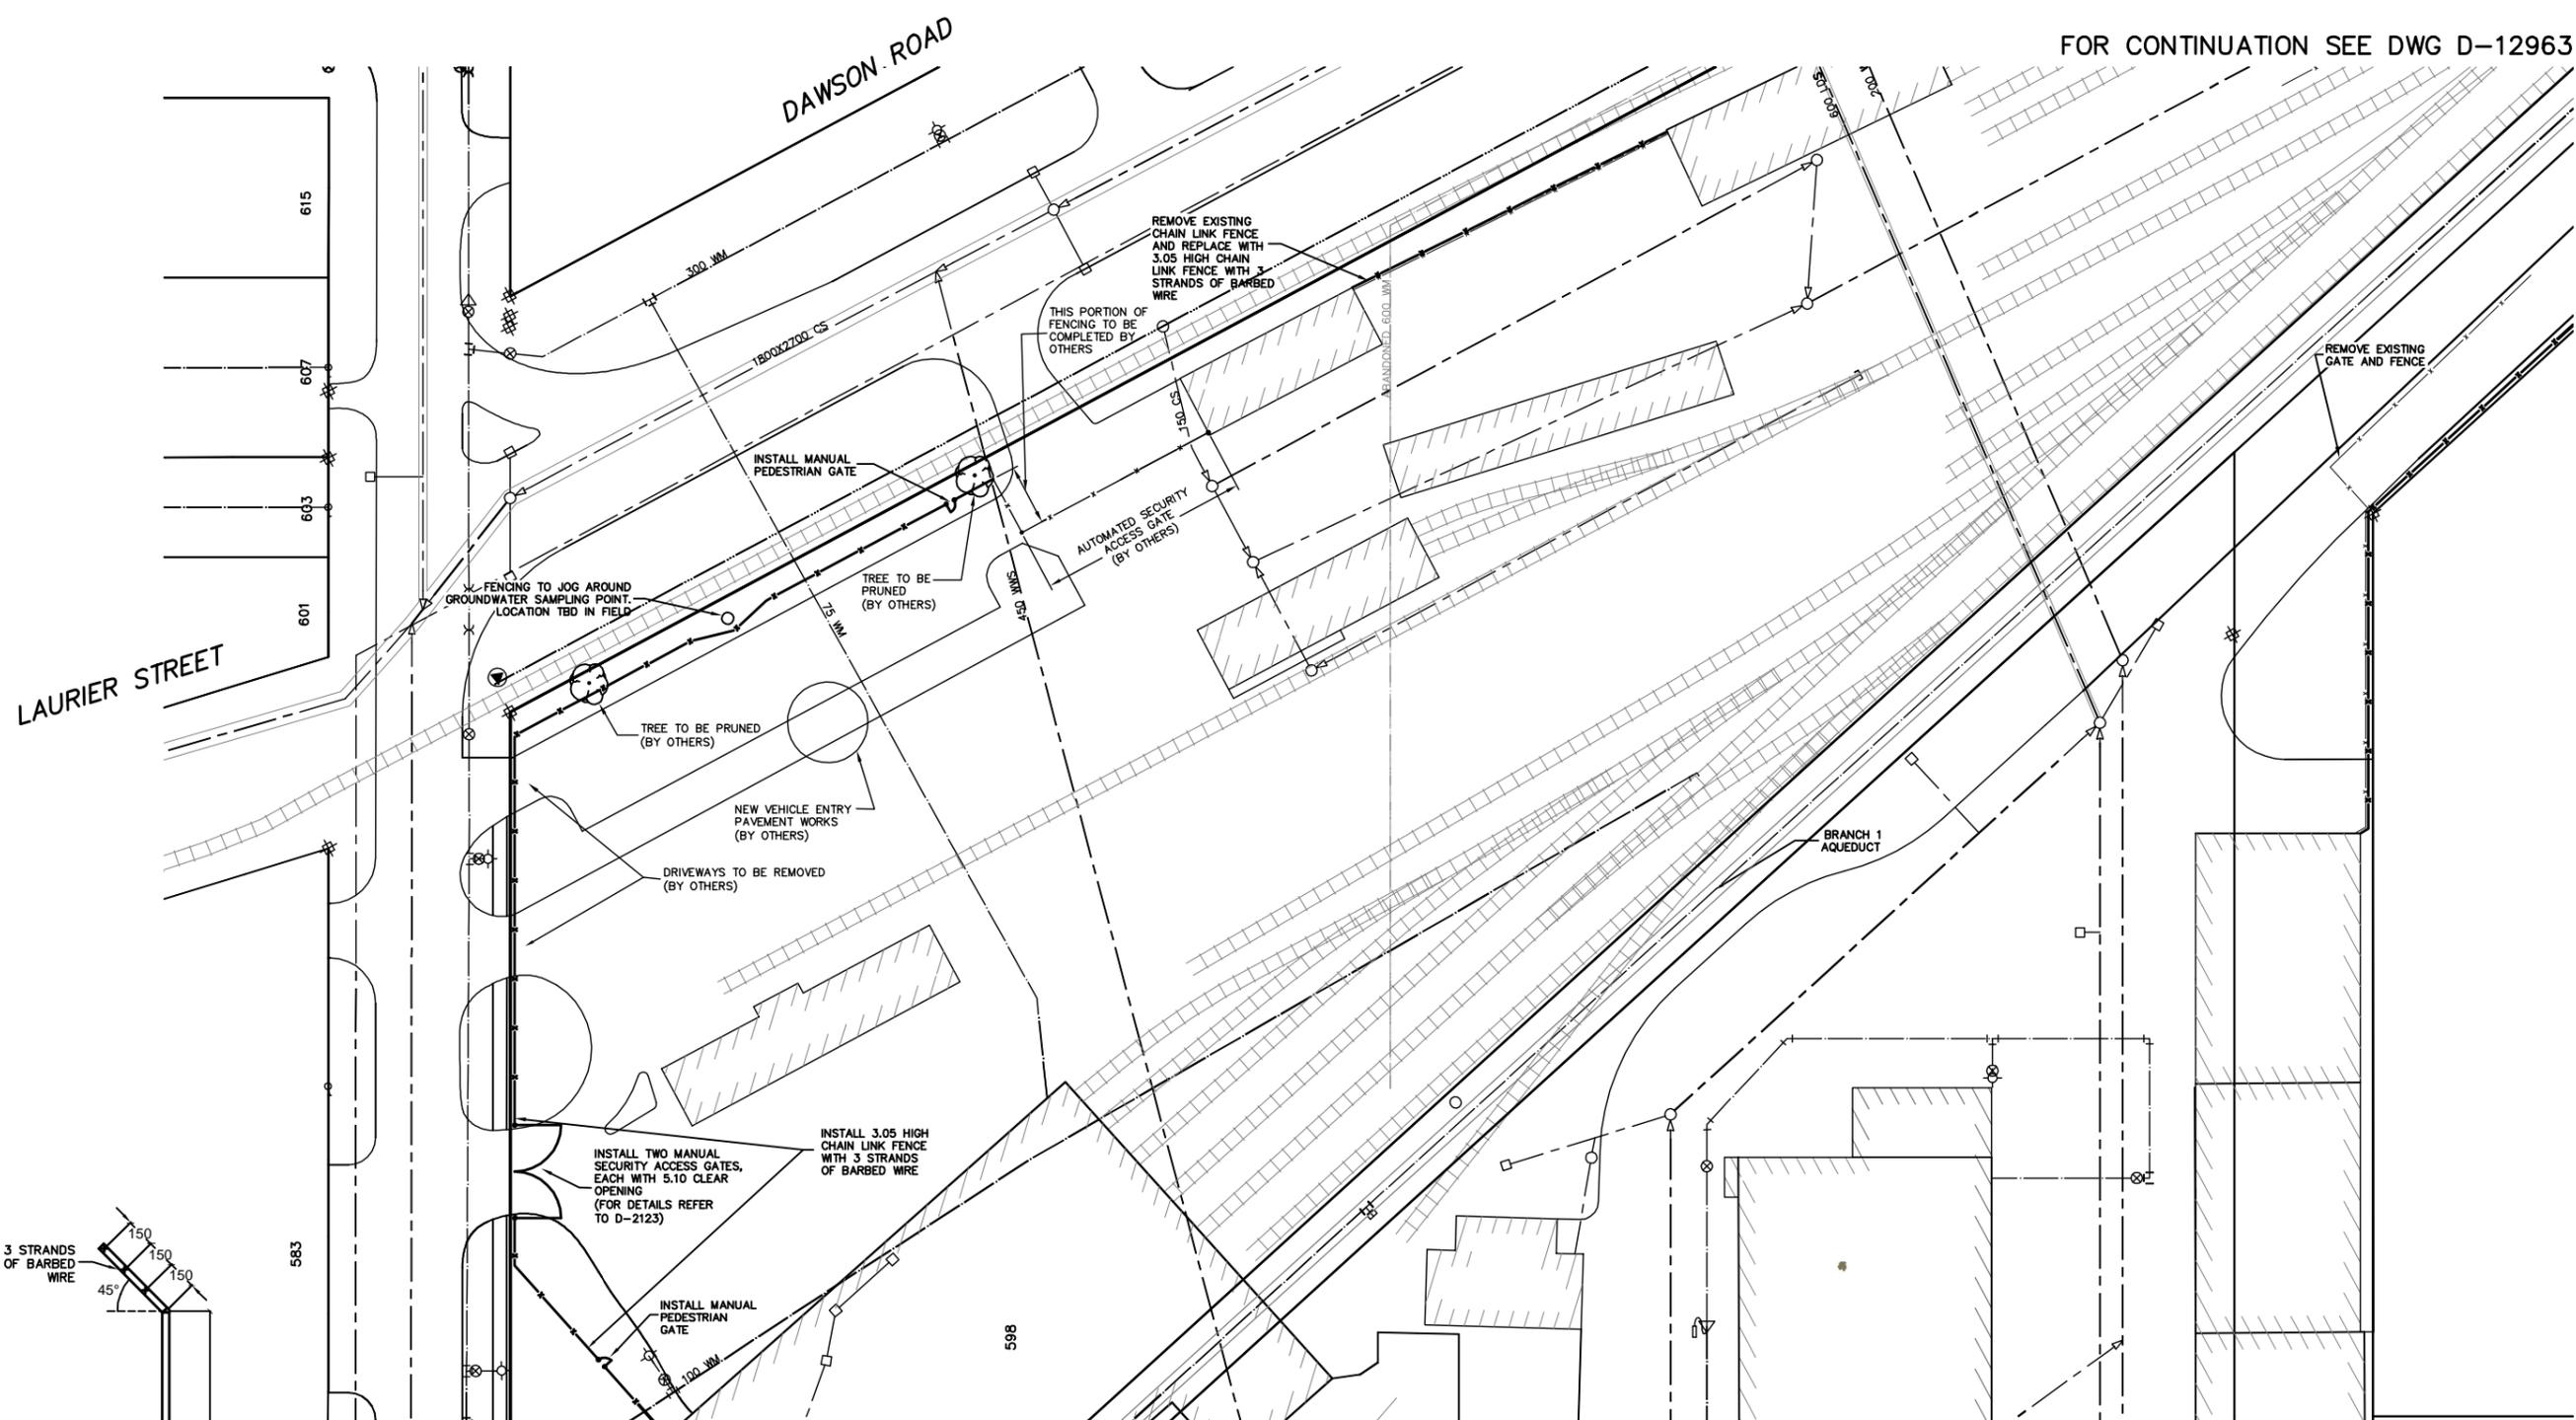

FENCE PROFILE DETAIL
SCALE: N.T.S.



<p>WARNING</p> <p>IF POWER EQUIPMENT OR EXPLOSIVES ARE TO BE USED FOR EXCAVATION ON THIS PROJECT THE CONTRACTOR MUST:</p> <ol style="list-style-type: none"> 1) NOTIFY THE GAS COMPANY OF THE PROPOSED LOCATION OF EXCAVATION. 2) TAKE PRECAUTION TO AVOID DAMAGE TO GAS COMPANY INSTALLATIONS. <p>SEE PROVINCIAL REGULATION 210/72 FOR DETAILS</p>	<p>LOCATION APPROVED UNDERGROUND STRUCTURES</p> <p>SUPV. U/G STRUCTURES COMMITTEE DATE</p> <p>NOTE:</p> <p>LOCATION OF UNDERGROUND STRUCTURES AS SHOWN ARE BASED ON THE BEST INFORMATION AVAILABLE BUT NO GUARANTEE IS GIVEN THAT ALL EXISTING UTILITIES ARE SHOWN OR THAT THE GIVEN LOCATIONS ARE EXACT. CONFIRMATION OF EXISTENCE AND EXACT LOCATION OF ALL SERVICES MUST BE OBTAINED FROM THE INDIVIDUAL UTILITIES BEFORE PROCEEDING WITH CONSTRUCTION.</p>	<p>B.M. ELEV.</p> <p>CONSTRUCTION COMPLETION DATE: YYYY MM DD</p>		<p>ENGINEER'S SEAL</p> <p>ORIGINAL SIGNED BY R.A. SOROKOWSKI 13.04.17</p>		<p>THE CITY OF WINNIPEG</p> <p>WATER AND WASTE DEPARTMENT ENGINEERING DIVISION</p> <p>PROPOSED SECURITY FENCE INSTALLATION AT 552/598 PLINGUET STREET NORTHEAST SITE PLAN</p> <p>SHEET 3 OF 4 CITY DRAWING NUMBER D-12862</p>																																		
		<table border="1"> <thead> <tr> <th>NO.</th> <th>REVISIONS</th> <th>DATE</th> <th>BY</th> </tr> </thead> <tbody> <tr> <td> </td> <td> </td> <td> </td> <td> </td> </tr> </tbody> </table>		NO.	REVISIONS		DATE	BY					<table border="1"> <tr> <td>DESIGNED BY</td> <td>JM</td> <td>CHECKED BY</td> <td>RAS</td> </tr> <tr> <td>DRAWN BY</td> <td>JB/TV</td> <td>APPROVED BY</td> <td>RAS</td> </tr> <tr> <td>SCALE:</td> <td></td> <td>RELEASED FOR CONSTRUCTION</td> <td></td> </tr> <tr> <td>HORIZONTAL</td> <td>1:375</td> <td>R.A. SOROKOWSKI</td> <td></td> </tr> <tr> <td>VERTICAL</td> <td></td> <td>DATE</td> <td>13.04.17</td> </tr> <tr> <td>DATE</td> <td>2013 04 17</td> <td>CONSULTANT DRAWING NUMBER</td> <td>-</td> </tr> <tr> <td>PLOT DATE:</td> <td>2013 04 17</td> <td>BID OPPORTUNITY:</td> <td>125-2013</td> </tr> </table>		DESIGNED BY	JM	CHECKED BY	RAS	DRAWN BY	JB/TV	APPROVED BY	RAS	SCALE:		RELEASED FOR CONSTRUCTION		HORIZONTAL	1:375	R.A. SOROKOWSKI		VERTICAL		DATE	13.04.17	DATE	2013 04 17	CONSULTANT DRAWING NUMBER	-	PLOT DATE:	2013 04 17
NO.	REVISIONS	DATE	BY																																					
DESIGNED BY	JM	CHECKED BY	RAS																																					
DRAWN BY	JB/TV	APPROVED BY	RAS																																					
SCALE:		RELEASED FOR CONSTRUCTION																																						
HORIZONTAL	1:375	R.A. SOROKOWSKI																																						
VERTICAL		DATE	13.04.17																																					
DATE	2013 04 17	CONSULTANT DRAWING NUMBER	-																																					
PLOT DATE:	2013 04 17	BID OPPORTUNITY:	125-2013																																					