
 


Drawing Schedule

| Number | Title |
|--------|---|
| L1 | Cover Sheet |
| L2 | Scope Plan |
| L3 | Layout Plan |
| L4 | Tree Protection / Demolition Plan |
| L5 | Grading Plan |
| M1 | Building and Service Line Piping Layout |
| M2 | Building and Piping Details |
| E1 | Electrical Plan |
| E2 | Electrical Details |

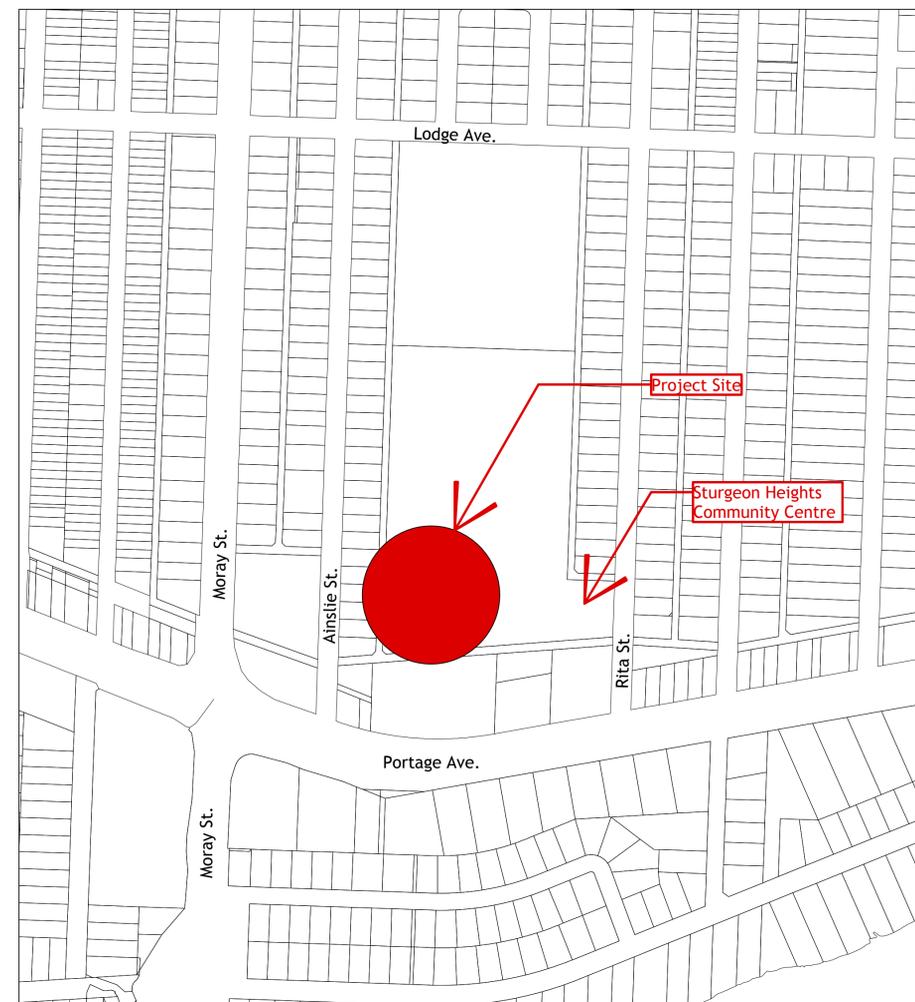

1 Context Map
L-1 Scale: 1:3000



1. This drawing shall not be used for construction unless signed and sealed by Landscape Architect.
2. Variations and modifications to the work shown will not be allowed without prior written consent of Landscape Architect.
3. Drawing and Specifications, as instruments of service, are the property of the Landscape Architect. The copyright is reserved in the name of the Landscape Architect. No reproduction may be made without the prior written consent of the Landscape Architect.
4. Contractors/bidders are hereby granted a limited licence to reproduce these drawings for the purposes of bidding. Such reproductions are not to be used for construction.

| No. | Date | Issue Notes |
|-----|---------|------------------------|
| C | 3/27/13 | For Bid Opportunity |
| B | 2/15/13 | For Pre Bid Opp Review |

| No. | Date | Issue Notes |
|-----|------|-------------|
| | | |

Consultant

Project Title
Sturgeon Heights CC
Spray Pad

Drawing Title
Cover Sheet

Drawing No.
L-1

of
Total Sheets