


- LEGEND**
- FLUORESCENT LUMINAIRE
 - WALL MOUNTED LUMINAIRE
 - CEILING MOUNTED LUMINAIRE
 - SPST SWITCH c/w PILOT LIGHT
 - SPST SWITCH
 - DUPLEX RECEPTACLE
 - TWIST LOCK DUPLEX RECEPTACLE
 - MOTOR
 - TELEPHONE & DATA OUTLET
 - HEAT DETECTOR
 - SMOKE DETECTOR
 - FIRE ALARM COMBINATION BUZZER AND STROBE
 - FIRE ALARM PULL STATION
 - COMBINATION EXIT SIGN, BATTERY PACK & EMERGENCY LIGHTING LAMPS
 - MOTORIZED DAMPER

MAIN LEVEL - ELECTRICAL ROOM - LIGHTING AND POWER
1/4" = 1'-0"

LUMINAIRE SCHEDULE					
TYPE	MANUFACTURER	CAT. NO.	LAMP	VOLTAGE	REMARKS
A	LITHONIA	L32 MV	2 - 32W T8	120V	SURFACE MOUNTED 48" LONG FLUORESCENT FIXTURE
B	LEVITON	49875	75W INCAND.	120V	ONE PIECE GLAZED PORCELAIN OUTLET BOX MTD. c/w CLAMP ON LAMP GUARD 12200-W
EX	AIM LITE	CXST0636-1-M-2MB-WHT	2 -MR16	6V	WALL MOUNTED c/w 2 MR 16 LAMPS. 120 VOLT SUPPLY. RED "EXIT" PICTOGRAM

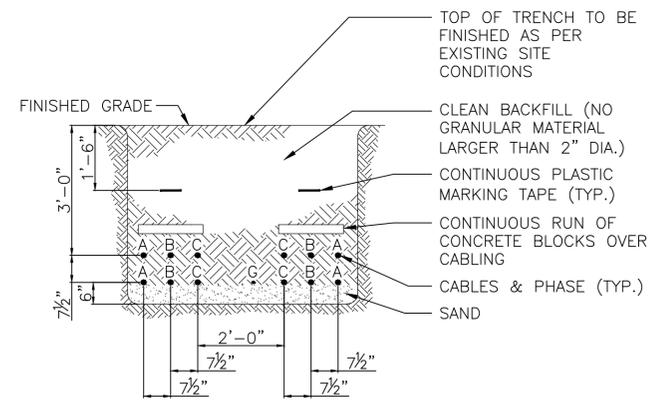

TRENCH DETAIL - MAIN INCOMING POWER CABLES
N.T.S.

<p>Conditions of Use</p> <p>Verify elevations and/or dimensions on drawing prior to use. Report any discrepancies to Dillon Consulting Limited.</p> <p>Do not scale dimensions from drawing.</p> <p>Do not modify drawing, re-use it, or use it for purposes other than those intended at the time of its preparation without prior written permission from Dillon Consulting Limited.</p>				DESIGN BLM	REVIEWED BY	<p>PAN AM POOL ELECTRICAL UPGRADE</p> <p style="text-align: right;">PROJECT NO. 137300</p>	
				DRAWN SCK	CHECKED BY		<p>ELECTRICAL</p> <p>LEGEND, SCHEDULE & DETAILS</p> <p style="text-align: right; font-size: 24pt;">E207</p>
DATE APR 3, 2013	SCALE AS NOTED						
				1 ISSUED FOR ADDENDUM No.1 13-12-10 SCK	0 ISSUED FOR BID OPPORTUNITY NUMBER 850-2013 13-11-20 SCK		