


- LEGEND**
- FLUORESCENT LUMINAIRE
  - WALL MOUNTED LUMINAIRE
  - CEILING MOUNTED LUMINAIRE
  - SPST SWITCH c/w PILOT LIGHT
  - SPST SWITCH
  - DUPLEX RECEPTACLE
  - TWIST LOCK DUPLEX RECEPTACLE
  - MOTOR
  - TELEPHONE & DATA OUTLET
  - HEAT DETECTOR
  - SMOKE DETECTOR
  - FIRE ALARM COMBINATION BUZZER AND STROBE
  - FIRE ALARM PULL STATION
  - COMBINATION EXIT SIGN, BATTERY PACK & EMERGENCY LIGHTING LAMPS
  - MOTORIZED DAMPER


**MAIN LEVEL - ELECTRICAL ROOM - LIGHTING AND POWER**  
1/4" = 1'-0"

LUMINAIRE SCHEDULE					
TYPE	MANUFACTURER	CAT. NO.	LAMP	VOLTAGE	REMARKS
A	LITHONIA	L32 MV	2 - 32W T8	120V	SURFACE MOUNTED 48" LONG FLUORESCENT FIXTURE
B	LEVITON	49875	75W INCAND.	120V	ONE PIECE GLAZED PORCELAIN OUTLET BOX MTD. c/w CLAMP ON LAMP GUARD 12200-W
EX	AIM LITE	CXST0636-1-M-2MB-WHT	2 -MR16	6V	WALL MOUNTED c/w 2 MR 16 LAMPS. 120 VOLT SUPPLY. RED "EXIT" PICTOGRAM

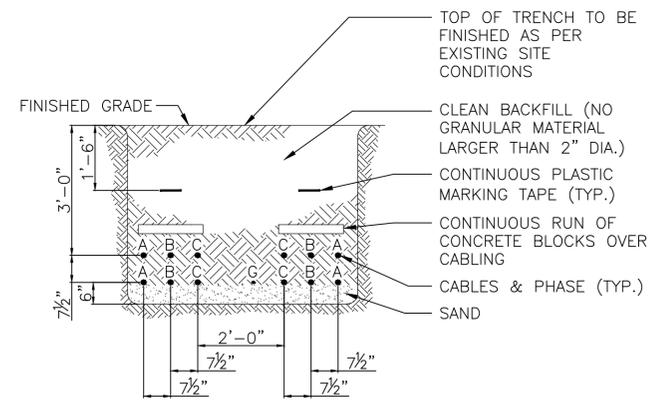

**TRENCH DETAIL - MAIN INCOMING POWER CABLES**  
N.T.S.

**Conditions of Use**  
Verify elevations and/or dimensions on drawing prior to use. Report any discrepancies to Dillon Consulting Limited.  
Do not scale dimensions from drawing.  
Do not modify drawing, re-use it, or use it for purposes other than those intended at the time of its preparation without prior written permission from Dillon Consulting Limited.

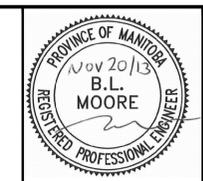

DESIGN	BLM	REVIEWED BY	
DRAWN	SCK	CHECKED BY	
DATE	APR 3, 2013		
SCALE	AS NOTED		
ISSUED FOR	ISSUED FOR BID OPPORTUNITY NUMBER 850-2013	DATE	13-11-20
BY	SCK	DATE	

<b>PAN AM POOL ELECTRICAL UPGRADE</b>		PROJECT NO. 137300
<b>ELECTRICAL LEGEND, SCHEDULE &amp; DETAILS</b>		SHEET NO. <b>E207</b>