


Printed: November 12, 2013, at 2:54:20 PM | Last Saved By: C.G.M.P.
 File: C:\13255\13108-000 (McDermot SRS Outfall Gate Chamber)\10 - electrical\Sheet11.dwg | Layout: 11

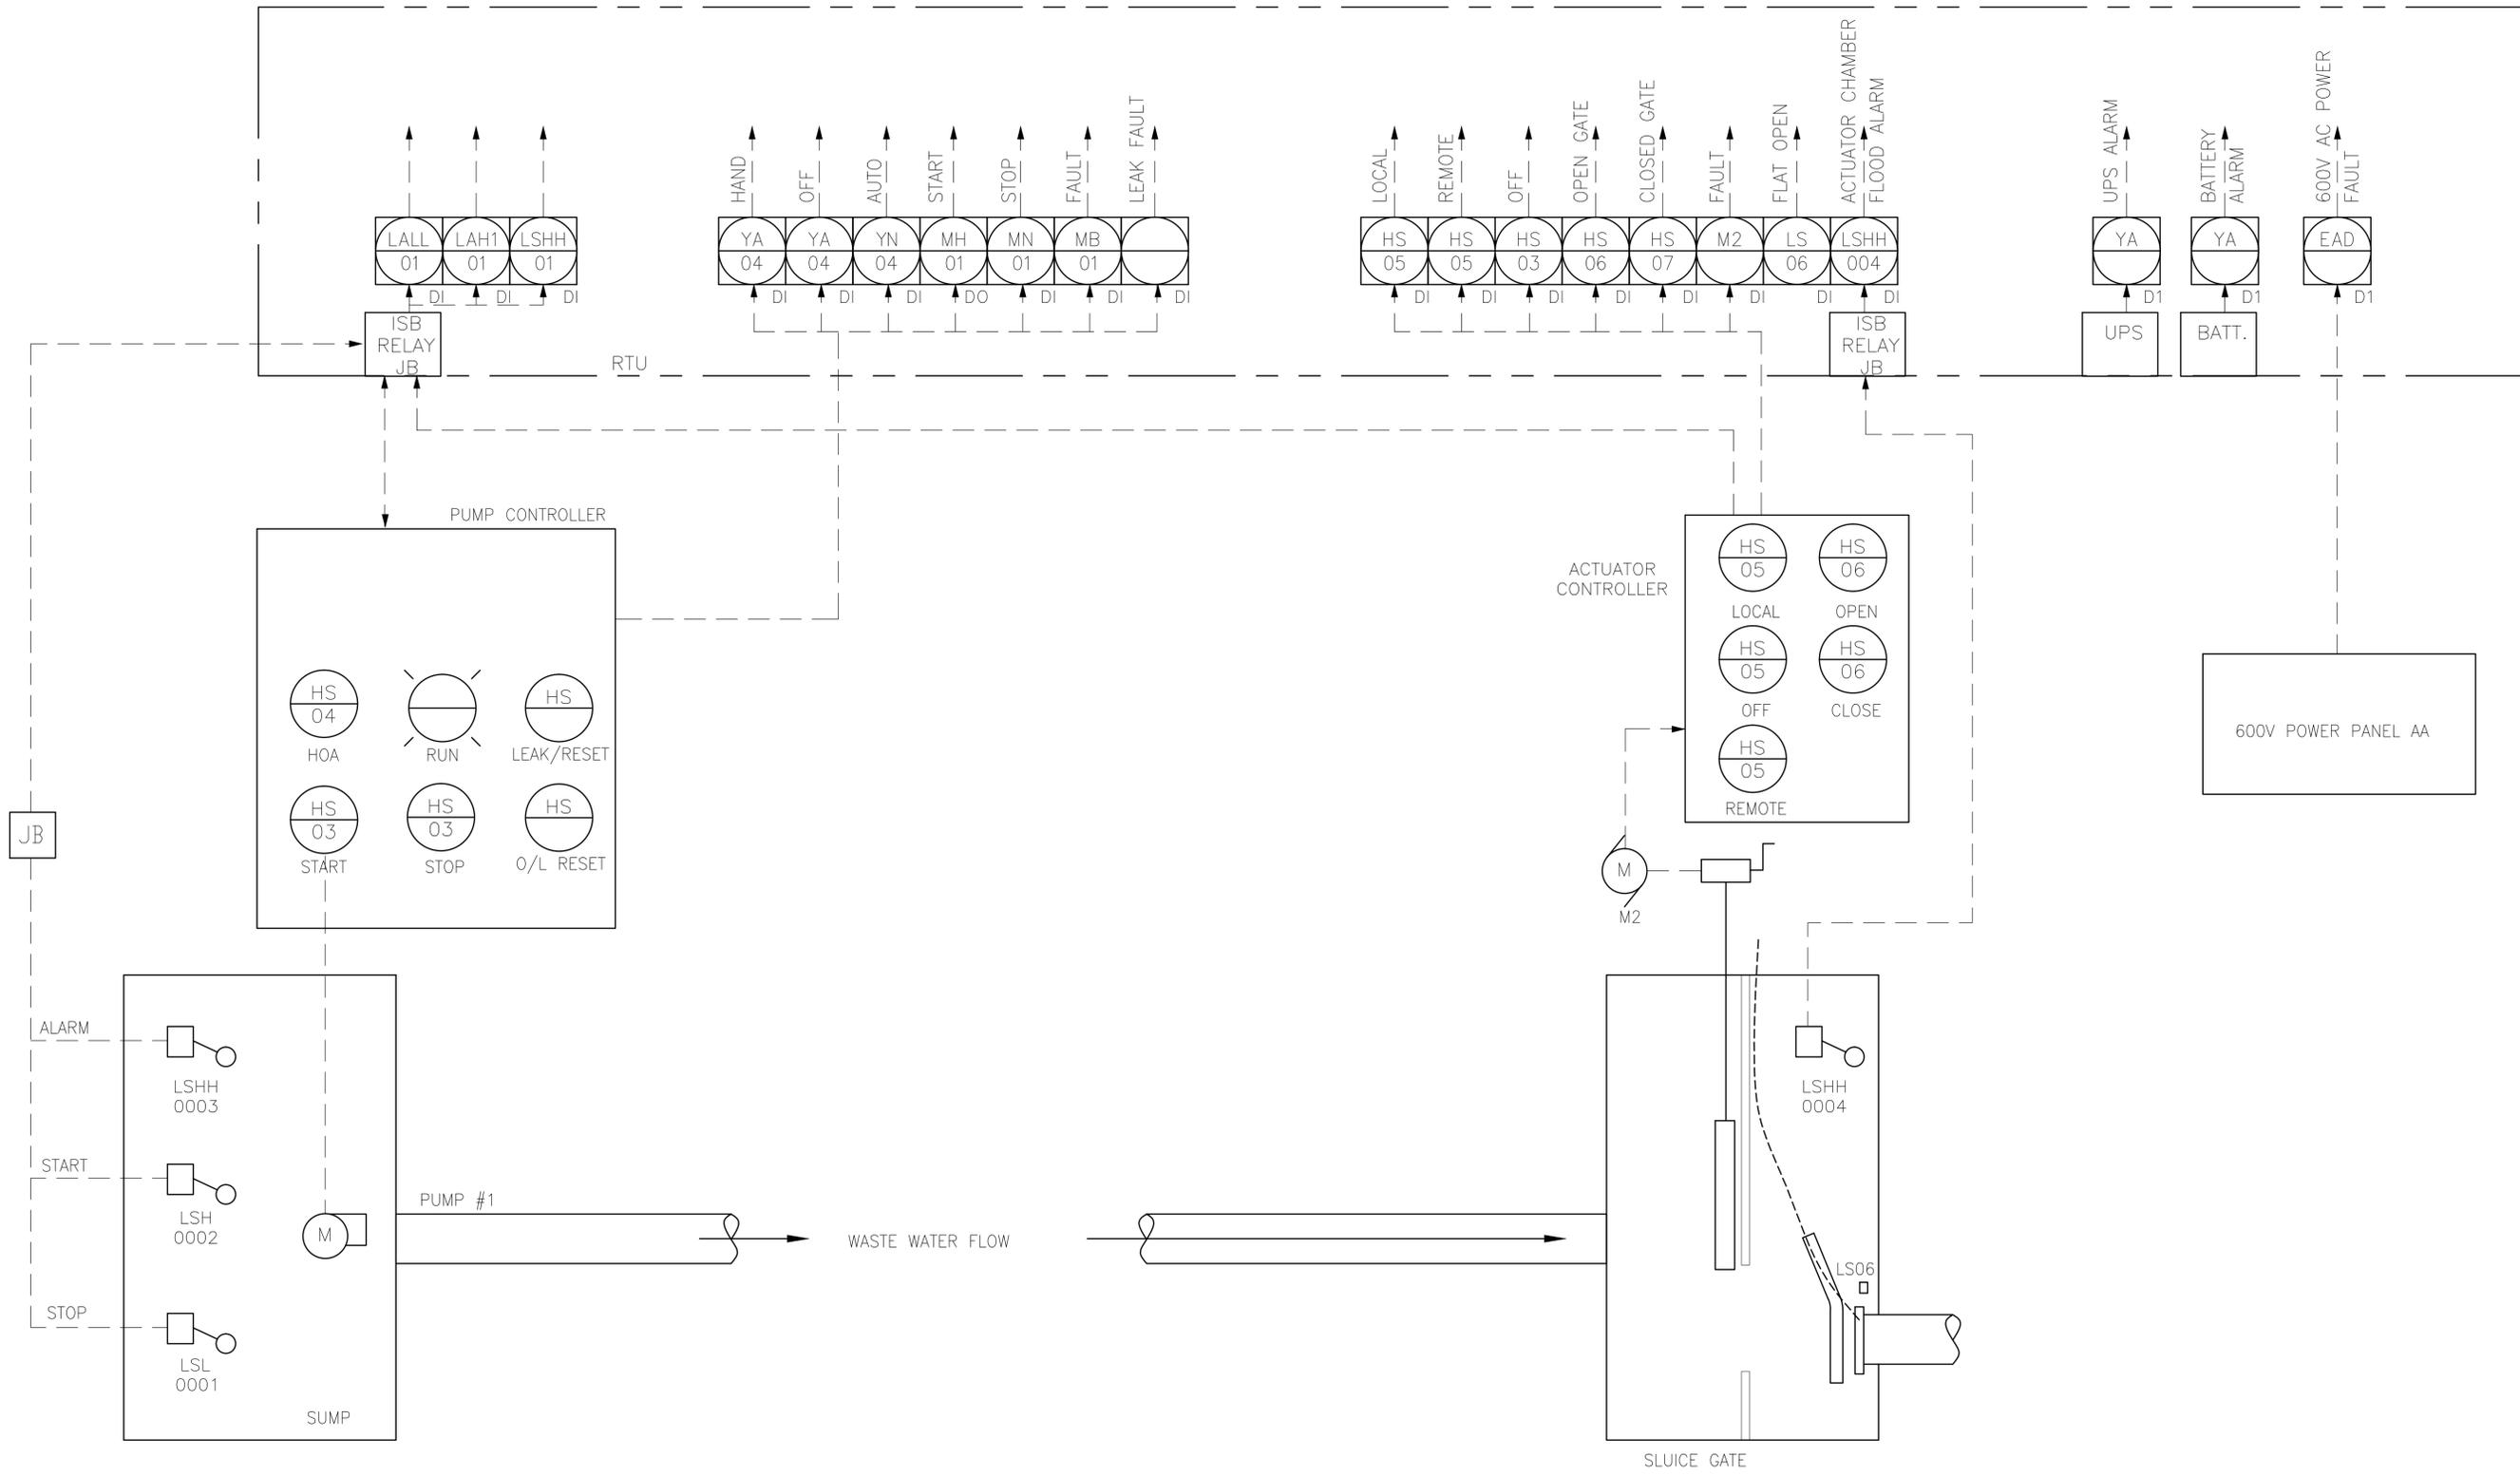

| | | | |
|-------------|--------------------------|---|-----------|
| | | MMM Group Limited Suite 111 - 93 Lombard Ave. Winnipeg, MB R3B 3B1 T. 204.943.3178 F. 204.943.4848 www.mmm.ca | |
| DESIGNED BY | J.D.S. | CHECKED BY | M.P./D.C. |
| DRAWN BY | R.D. | APPROVED BY | K.H. |
| HOR. SCALE | AS NOTED | RELEASED FOR CONSTRUCTION | |
| VERT. SCALE | AS NOTED | | |
| No. | REVISIONS | DATE | BY |
| B | ISSUED FOR TENDER | 13 11 12 | M.P. |
| A | ISSUED FOR CLIENT REVIEW | 13 11 04Z | M.P. |
| | | 13.10.16 | |
| | | 13.10.16 | |

ENGINEER'S SEAL

BID OPPORTUNITY: 912-2013
PLOT DATE: 13.10.16

THE CITY OF WINNIPEG
 WASTE AND WATER DEPARTMENT
 Winnipeg

CONSULTANT DRAWING No.: I1
 SHEET 14 OF 22
 CITY DRAWING No.: LD-7259

OUTFALL GATE CHAMBER UPGRADES
McDERMOT
SRS OUTFALL GATE CHAMBER
 PIPING & INSTRUMENTATION DIAGRAM