



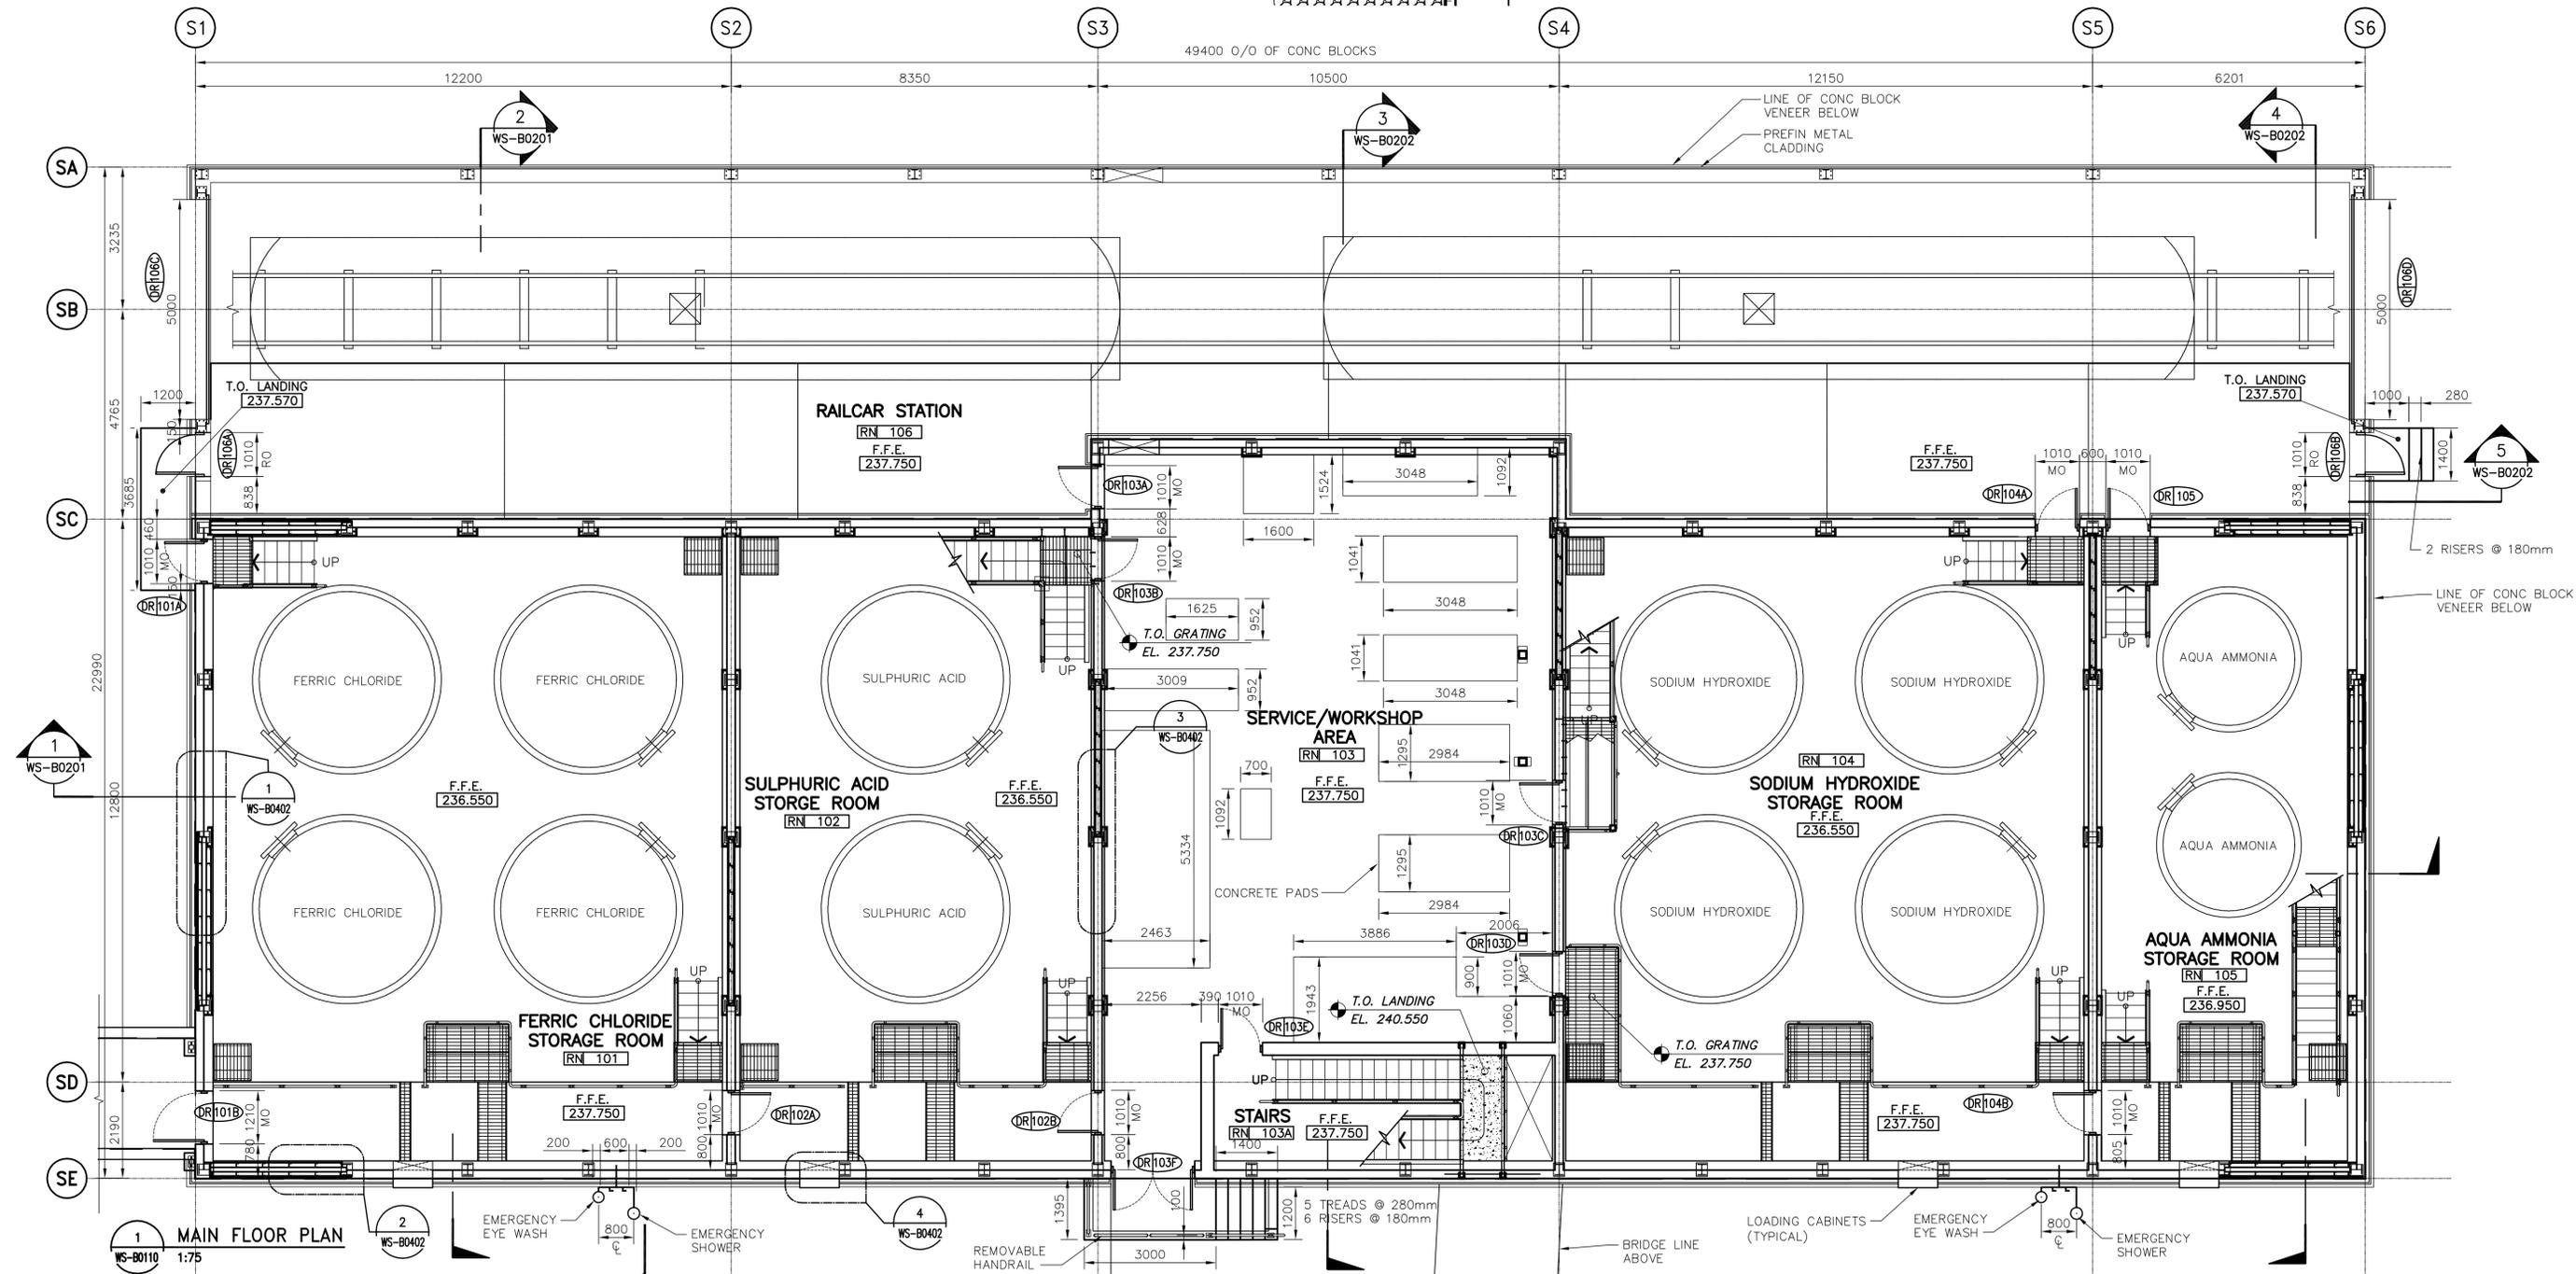

2 TYP SECTION
WS-B0110 1:25

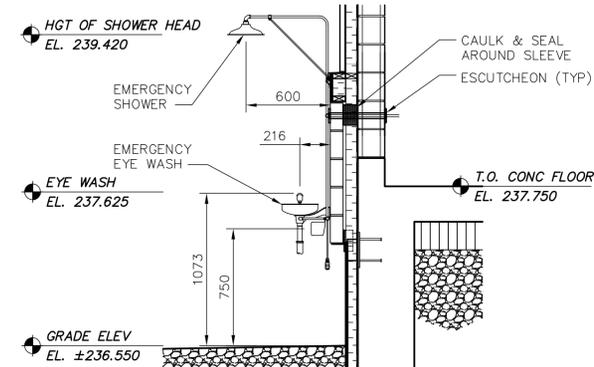

1 MAIN FLOOR PLAN
WS-B0110 1:75

AECOM
As of January 3, 2009, EarthTech became AECOM Canada Ltd.

AECOM AS-CONSTRUCTED
SIG. _____ DATE _____



NO.	REVISIONS	DATE	BY	DATE
08	792-2006 FI-0-170-FC	08/08/15	AG	
07	792-2006 FI-0-162-FC-R1	08/07/23	AL	
06	792-2006 FI-0-162-FC	08/06/10	AL	
05	792-2006 FI-0-111-FC	08/01/10	AL	
04	792-2006 FI-0-071-FC	07/10/10	AL	
03	ISSUED FOR CONSTRUCTION	07/06/01	AL	
02	792-2006 ADDENDUM 5	07/04/11	AL	
01	792-2006 ADDENDUM 3	07/03/30	AL	
00	ISSUED FOR TENDER	07/01/31	AL	

CH2M HILL
Frederickson Cooper ARCHITECTS

DESIGNED BY: NC
DRAWN BY: AL
SCALE: AS SHOWN

CHECKED BY: LK
APPROVED BY: AHL
RELEASED FOR CONSTRUCTION BY: R. SOROKOWSKI

DATE: 2006/09/01
DATE: 2007/01/31

ENGINEER'S SEAL
ORIGINAL SIGNED BY: NEIL COOPER
DATE: 2007/01/31

CONSULTANT DRAWING NO. WS-B0110

THE CITY OF WINNIPEG
WATER AND WASTE DEPARTMENT
ENGINEERING DIVISION

WATER TREATMENT PLANT
BULK CHEMICAL STORAGE
SODIUM HYPOCHLORITE AND CHEMICAL BUILDING

ARCHITECTURAL
MAIN FLOOR PLAN

CITY FILE NUMBER
SHEET OF
CITY DRAWING NUMBER
1-0601S-B0002-001-09