
## NOTES:


1. EXISTING SENSORS FEED FROM AREAS BELOW TO THE SEWAGE PLANT BELOW.

## **DEMOLITION NOTES:**

 - A. ALL EQUIPMENT BEING REMOVED SHALL BE MADE AVAILABLE TO THE CITY OF WINNIPEG AND DELIVERED TO THEM ON PACIFIC AVENUE.
- B. ANY EQUIPMENT WHICH WOULD BE REQUIRED TO RE-ENERGIZE THE PUMPS (INCLUDES STARTERS) SHALL BE PROPERLY DISCONNECTED AND STORED ON SITE IN CASE OF AN EMERGENCY.

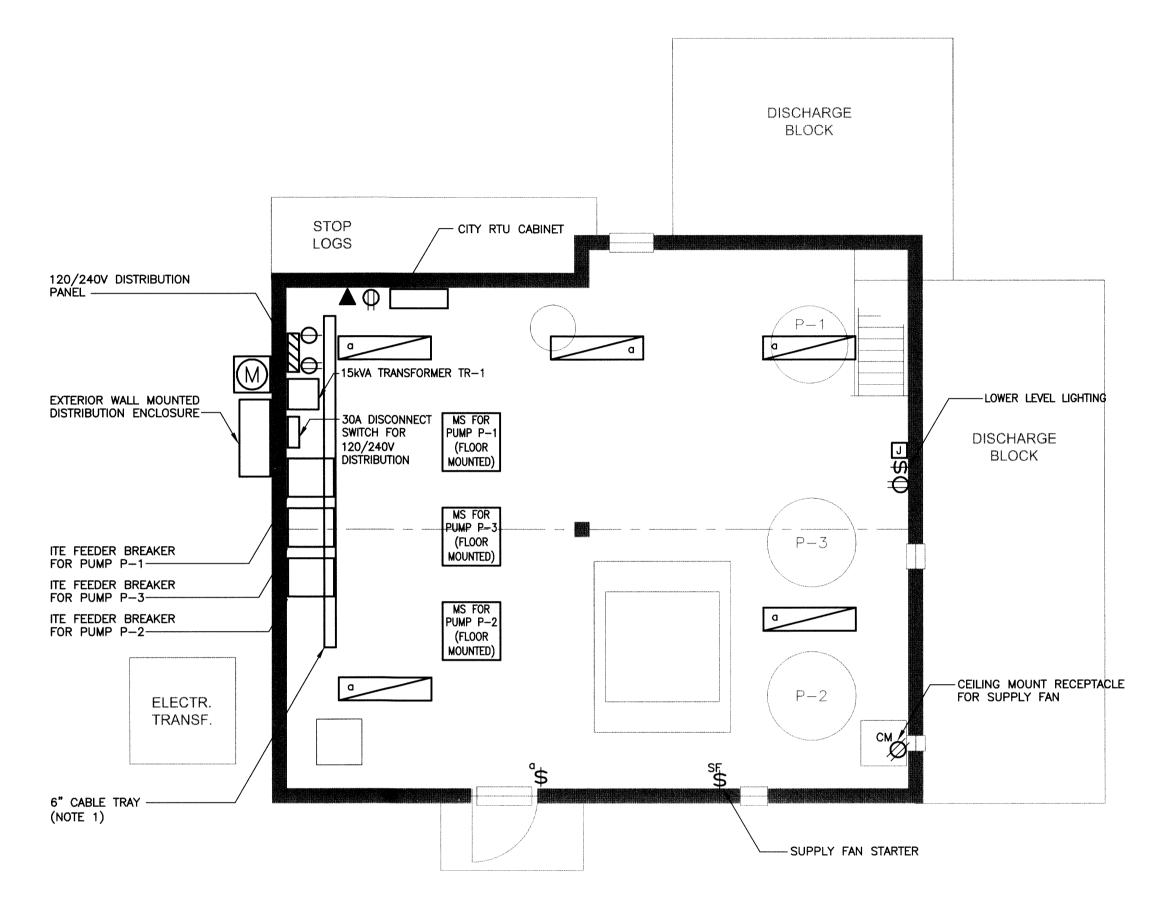





**APEGIN** 

Certificate of Authorization

KGS Group

No. 245

## **LEGEND:**

4' FLUORESCENT LIGHT
a DENOTES CONTROLLING CIRCUIT

DUPLEX RECEPTACLE

TWIST-LOCK SINGLE RECEPTACLE

SWITCH

X DENOTES ITEM(S) CONTROLLED

JUNCTION BOX

1ø MOTOR LOAD

TELEPHONE

FIELD BOOK #:

POSTED TO LBIS

DESIGNED BY DDW/MAM

CHECKED BY DDW/MAM

DRAWN BY GCN

APPROVED BY

HUR. SCALE N.T.S.

POSTED TO LBIS

N.T.S.

RELEASED FOR CONSTRUCTION


14/08/18 AP VERTICAL N.T.S.

NO. REVISIONS

DATE

BY DATE

2014 01 13 DATE

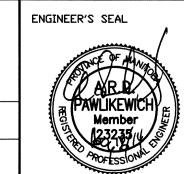

M-E02



## THE CITY OF WINNIPEG water and waste department

FLOOD PUMPING STATION UPGRADES

SHEET 1

MARION STATION
ELECTRICAL

POWER, SYSTEMS AND LIGHTING PLAN EXISTING

CITY DRAWING NUMBER

1-0159F-E0004-001