


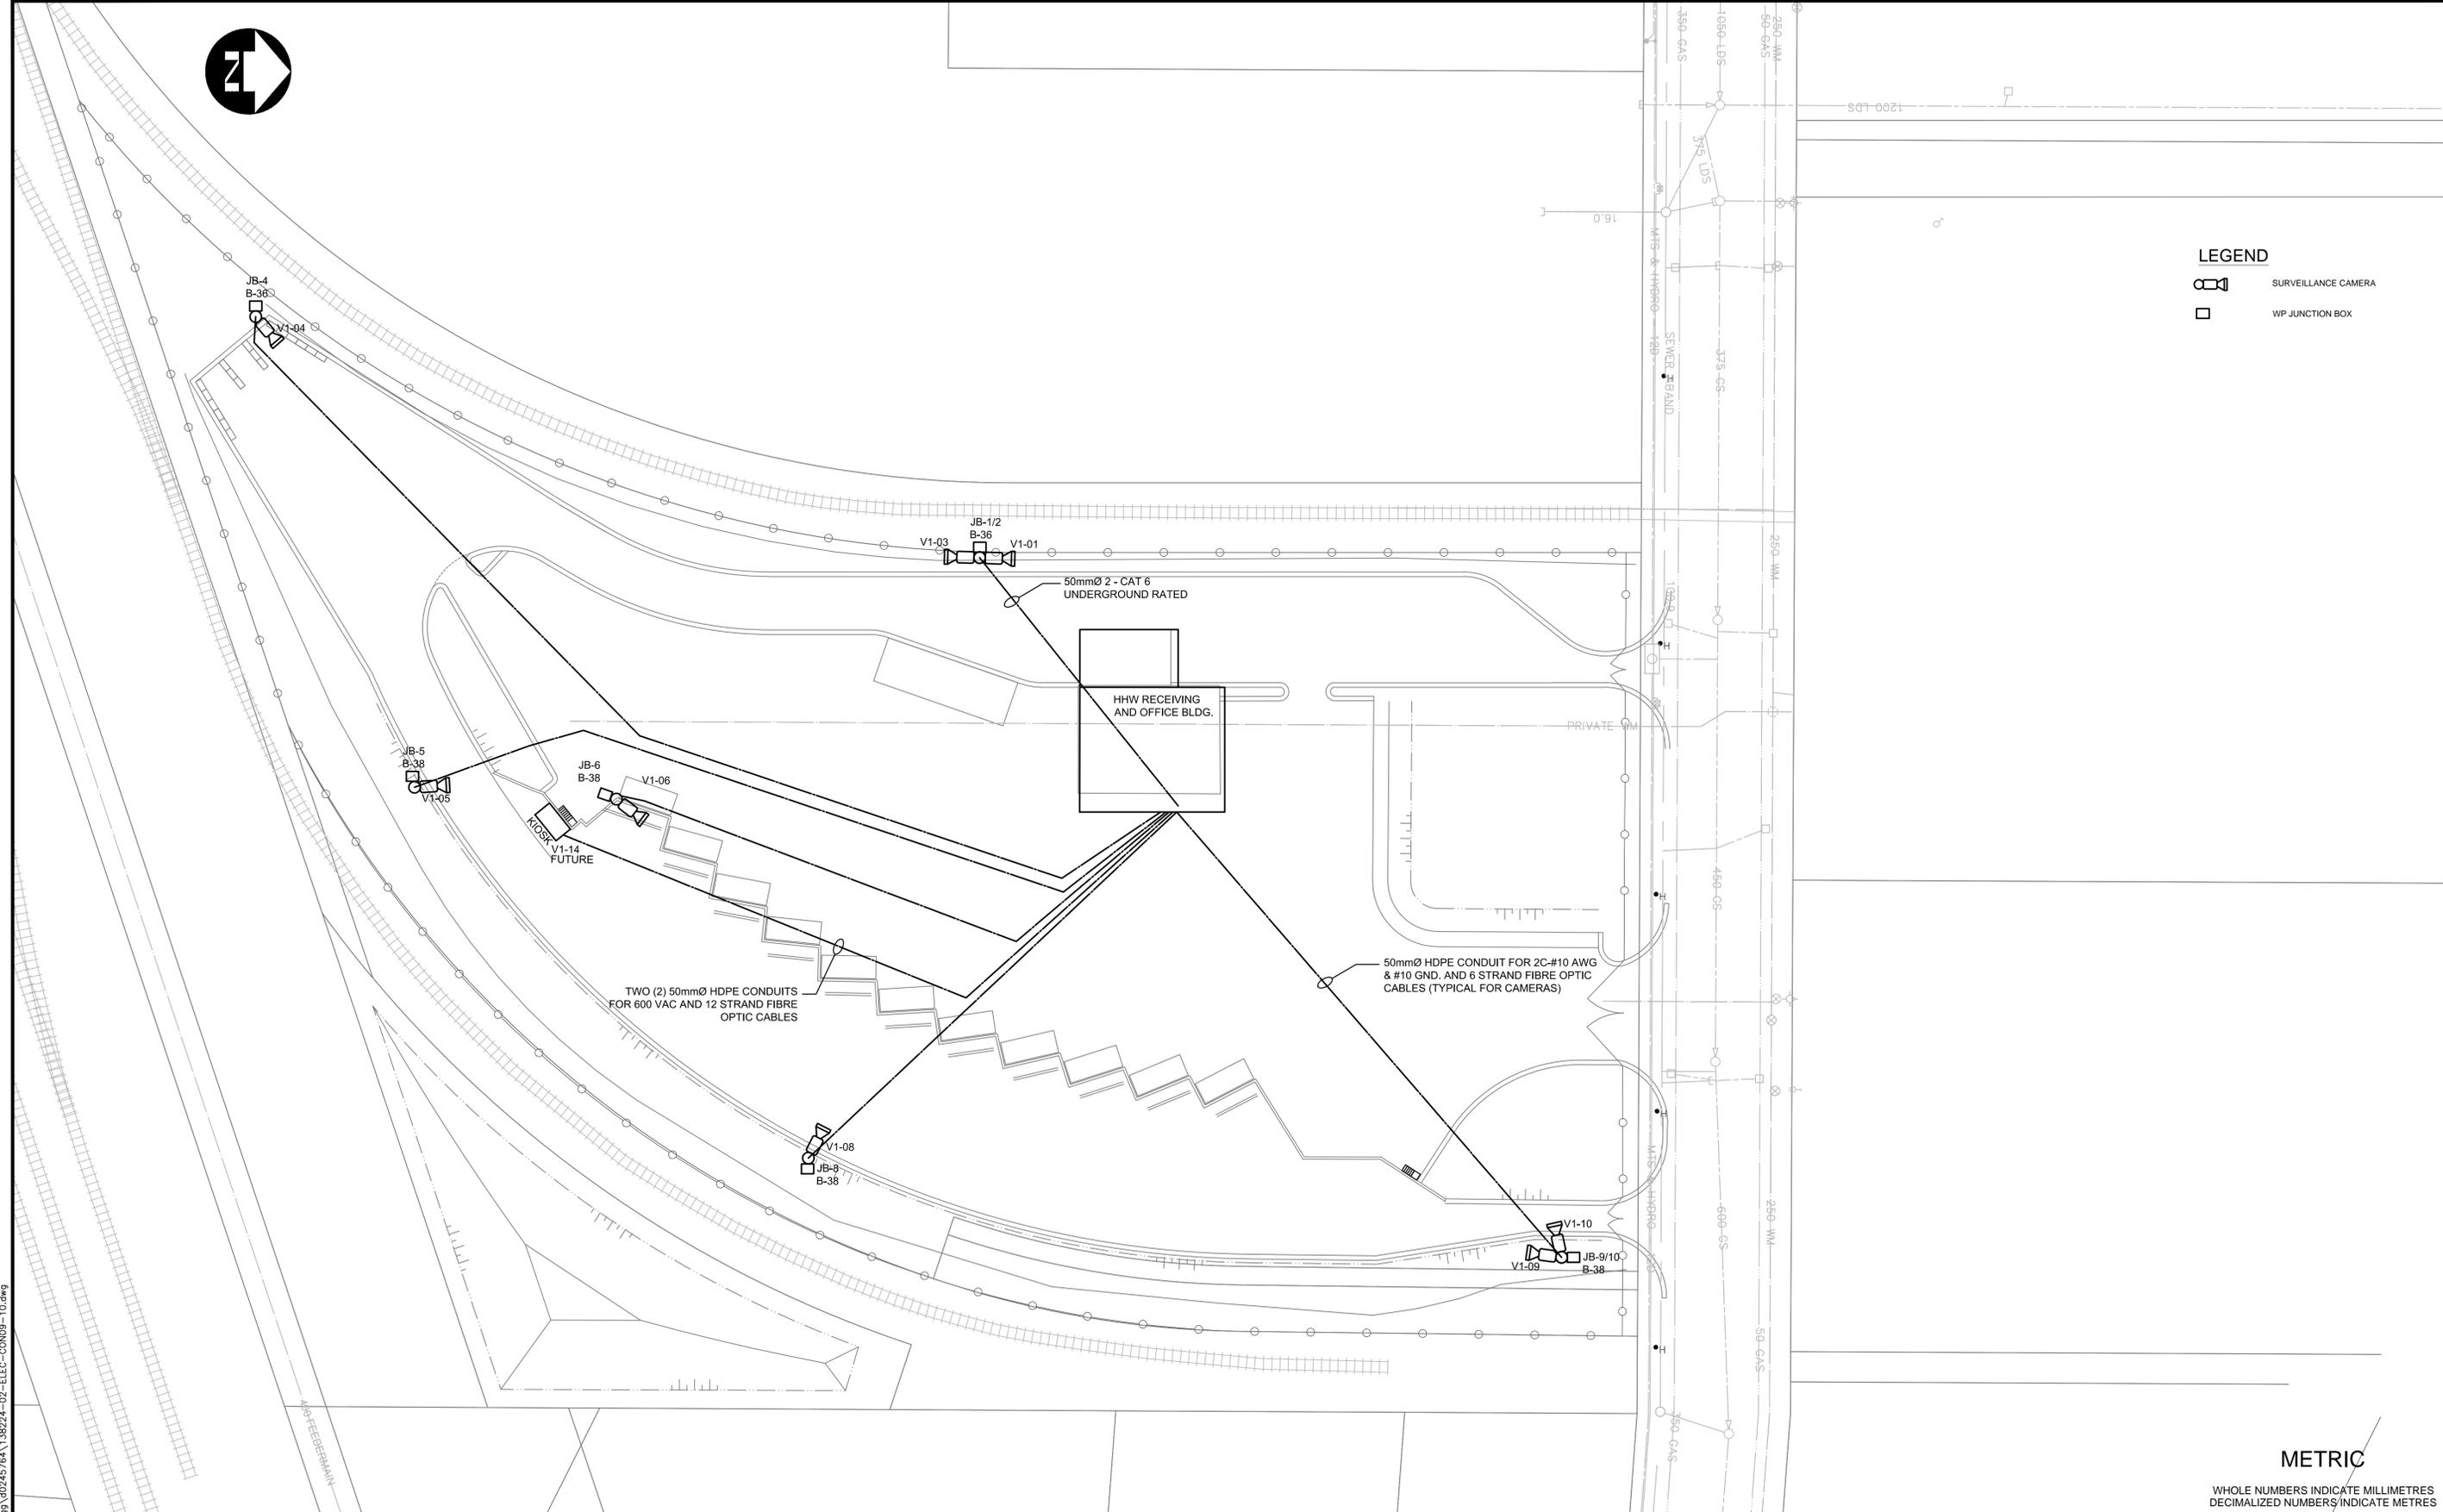

LEGEND

	SURVEILLANCE CAMERA
	WP JUNCTION BOX




METRIC
WHOLE NUMBERS INDICATE MILLIMETRES
DECIMALIZED NUMBERS INDICATE METRES

C:\projects\winnipeg\working_directory\active\4999_d024576A\138224-02-ELEC-CO009-10.dwg



B.M. ELEV.	DESIGNED BY	BLM
	DRAWN BY	SCK
	CHECKED BY	BLM
	APPROVED BY	
	HOR. SCALE	AS NOTED
	VERTICAL	
1 ISSUED FOR TENDER	16/03/04	ARR
NO. REVISIONS	DATE	BY

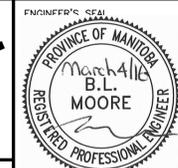

THE CITY OF WINNIPEG
PUBLIC WORKS DEPARTMENT

4R WINNIPEG DEPOT
PACIFIC AVENUE

SITE PLAN SECURITY CAMERAS LAYOUT

CITY DRAWING NUMBER: 1-0851A-E0010-001
SHEET 42 OF 43
CONSULTANT DRAWING NUMBER: E-10

CONSULTANT PROJECT NUMBER: 13-8224

RELEASED FOR CONSTRUCTION