



LIGHTING DISTRIBUTION SCHEMATIC
SCALE: N.T.S.

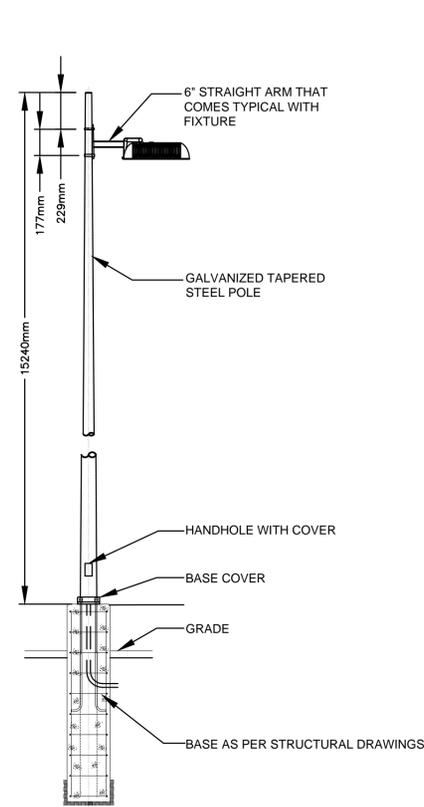

TYPICAL SITE LIGHTING POLE MOUNTING DETAIL
SCALE: N.T.S.

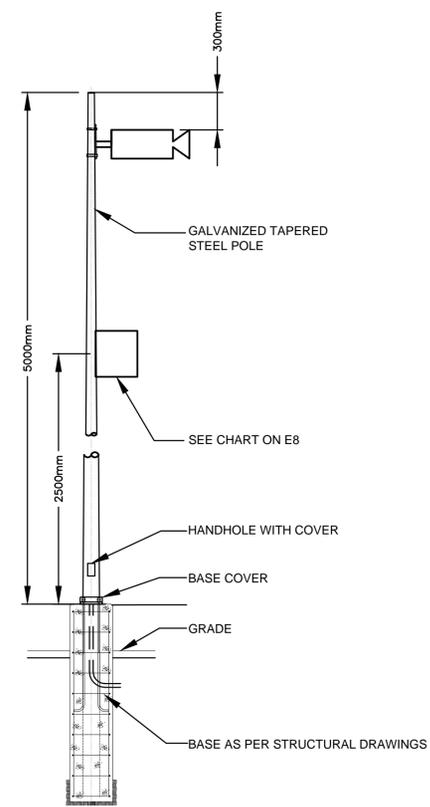


TYPICAL SECURITY CAMERA POLE MOUNTING DETAIL
SCALE: N.T.S.

METRIC
WHOLE NUMBERS INDICATE MILLIMETRES
DECIMALIZED NUMBERS INDICATE METRES



B.M. ELEV.	DESIGNED BY	BLM
	DRAWN BY	SCK
	CHECKED BY	BLM
	APPROVED BY	ARR
	HOR. SCALE	AS NOTED
	VERTICAL	
1 ISSUED FOR TENDER	16/03/04	ARR
NO. REVISIONS	DATE	BY

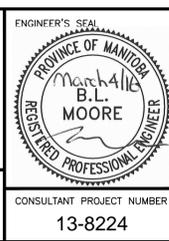

THE CITY OF WINNIPEG
PUBLIC WORKS DEPARTMENT

4R WINNIPEG DEPOT
PACIFIC AVENUE

SITE - ELECTRICAL DETAILS

CITY DRAWING NUMBER: 1-0851A-E0011-001
SHEET 43 OF 43
CONSULTANT DRAWING NUMBER: E-11

CONSULTANT PROJECT NUMBER: 13-8224

C:\projects\winnipeg\working_directory\active\4099\40245764\138224-02-ELEC-CO011.dwg