



- PLUMBING SYMBOLS**
- COLD WATER (POTABLE DOMESTIC)
  - HOT WATER (POTABLE DOMESTIC)
  - RECIRC. HOT WATER (POTABLE DOMESTIC)
  - SANITARY OR STORM LINE
  - VENT LINE
  - CLEAN OUT
  - PIPE CAPPED OFF
  - BALANCE FITTING
  - GATE VALVE
  - CHECK VALVE
  - GLOBE VALVE
  - ROOF HOPPER
  - P-1 PLUMBING FIXTURE NUMBER
  - AIR CHAMBER
  - G GAS LINE (NATURAL)
  - ACID WASTE
  - PLUG COCK
  - SHOCK ARRESTOR
  - UNION
  - COMPRESSED AIR
  - FIRE LINE
  - WEEPING TILE
  - FOS FUEL OIL SUPPLY
  - FOR FUEL OIL RETURN
  - RWL RAIN WATER LEADER

1 PLAN AT ELEV. 746'-0", 746'-6" & 750'-0"  
 M 405 405 1/8" = 1'-0"

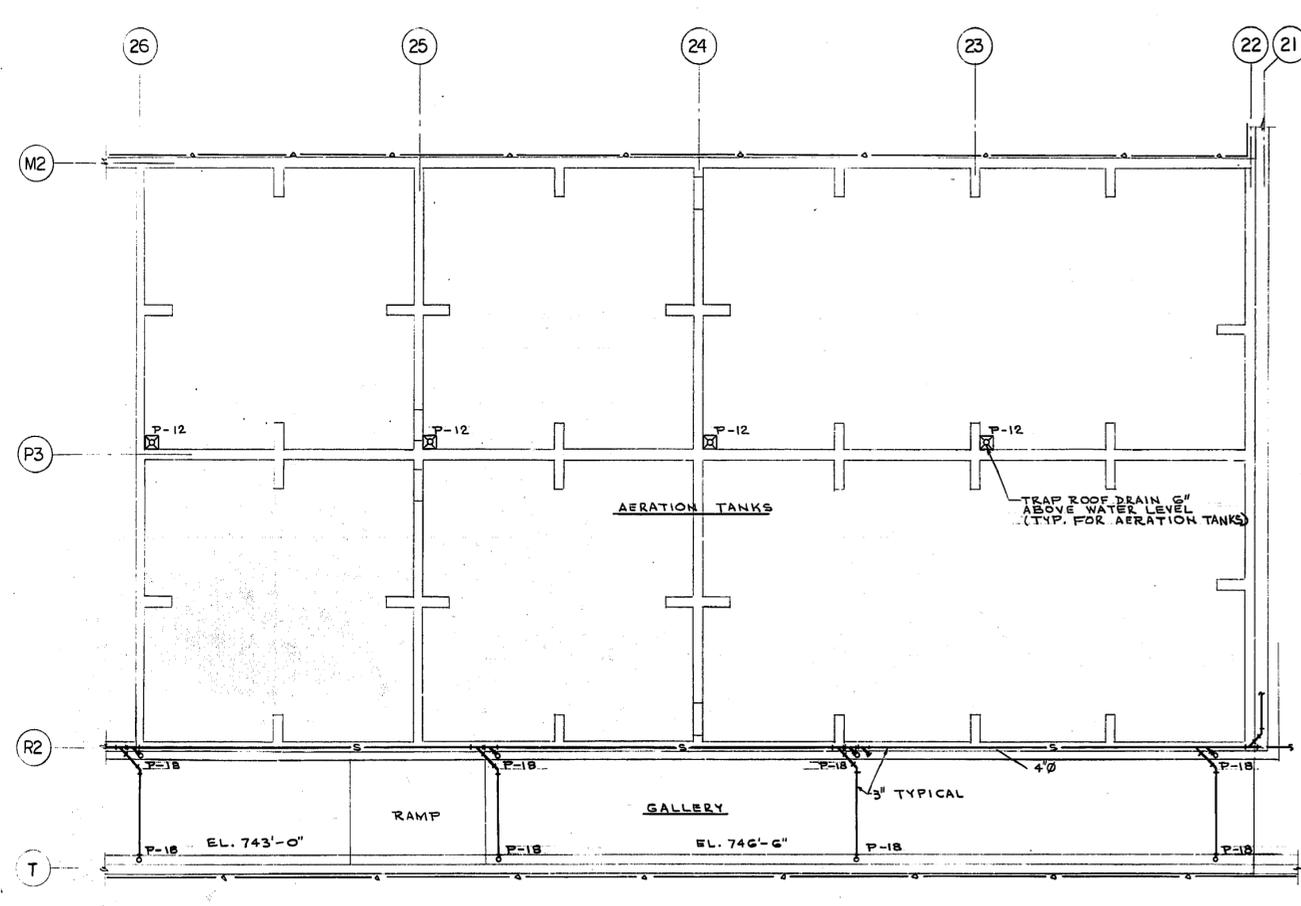

2 PLAN AT ELEV. 743'-0" & 746'-6"  
 M 405 405 1/8" = 1'-0"

AS - BUILT		
DATE	FB. NO.	PAGE
20-7-74		

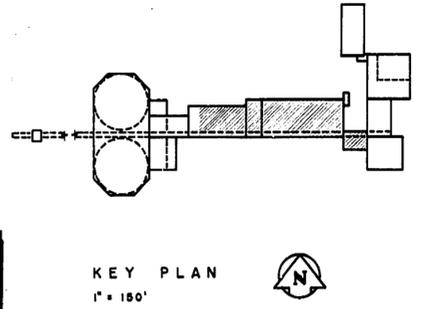

**MICROFILMED** MAR 31 1980

REVISIONS		
NO.	DATE	DESCRIPTION

THE METROPOLITAN CORPORATION OF GREATER WINNIPEG  
 WATERWORKS & WASTE DISPOSAL DIVISION  
 A. PENMAN - DIRECTOR

**W.L. WARDROP & ASSOCIATES LTD.**  
 ENGINEERING CONSULTANTS  
 WINNIPEG - THUNDER BAY - REGINA - TORONTO

**SOUTH END WATER POLLUTION CONTROL CENTRE**  
 PRIMARY CLARIFIER & PRIMARY SLUDGE PUMPING BLDGS. - MECHANICAL PLUMBING

SCALE: AS SHOWN	ENGINEER OF DESIGN: <i>G.J. Maguet</i>
DATE: OCT. 1971	ENGINEER OF OPERATIONS: <i>[Signature]</i>
APPROVED (W.L.W.): <i>[Signature]</i>	APPROVED (M.E.C.): <i>[Signature]</i>
W.L.W. FILE NO. 70012-01-M405	DRAWING NO. S.E.P. - 64

