


GROUND FLOOR PLAN - PART B

1:100

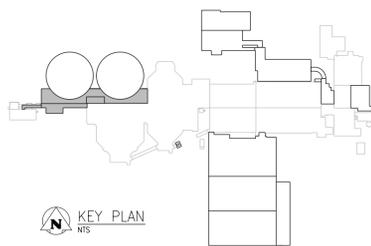

KEY PLAN
NTS



NO.	REVISIONS	DATE	DESIGN	CHECK
00	ISSUED FOR TENDER - B.O. 899-2015	01/2016	P.K.	I.T.

PLOT DATE: 2016\01\28

CH2MHILL.
SNC-LAVALIN

DESIGNED BY: T. TRAN
DRAWN BY: P. KWONG
SCALE: 1:100
DATE: 2016/01/29

CHECKED BY: D. LE
APPROVED BY: H.T. FREIHAMMER
ISSUED FOR CONSTRUCTION BY: T. TURZAK
DATE: 2016/01/29


CONSULTANT NO.: 474248



THE CITY OF WINNIPEG
Winnipeg WATER AND WASTE DEPARTMENT

SOUTH END WATER POLLUTION CONTROL CENTRE
SEWPPC UPGRADING/EXPANSION PROJECT
MECHANICAL
SECONDARY CLARIFIERS 4 AND 5
PLUMBING - GROUND FLOOR PLAN - PART B

CITY DRAWING NUMBER: 1-0102-MGAD-S506
SHEET: 001
REV.: 00
SIZE: A1

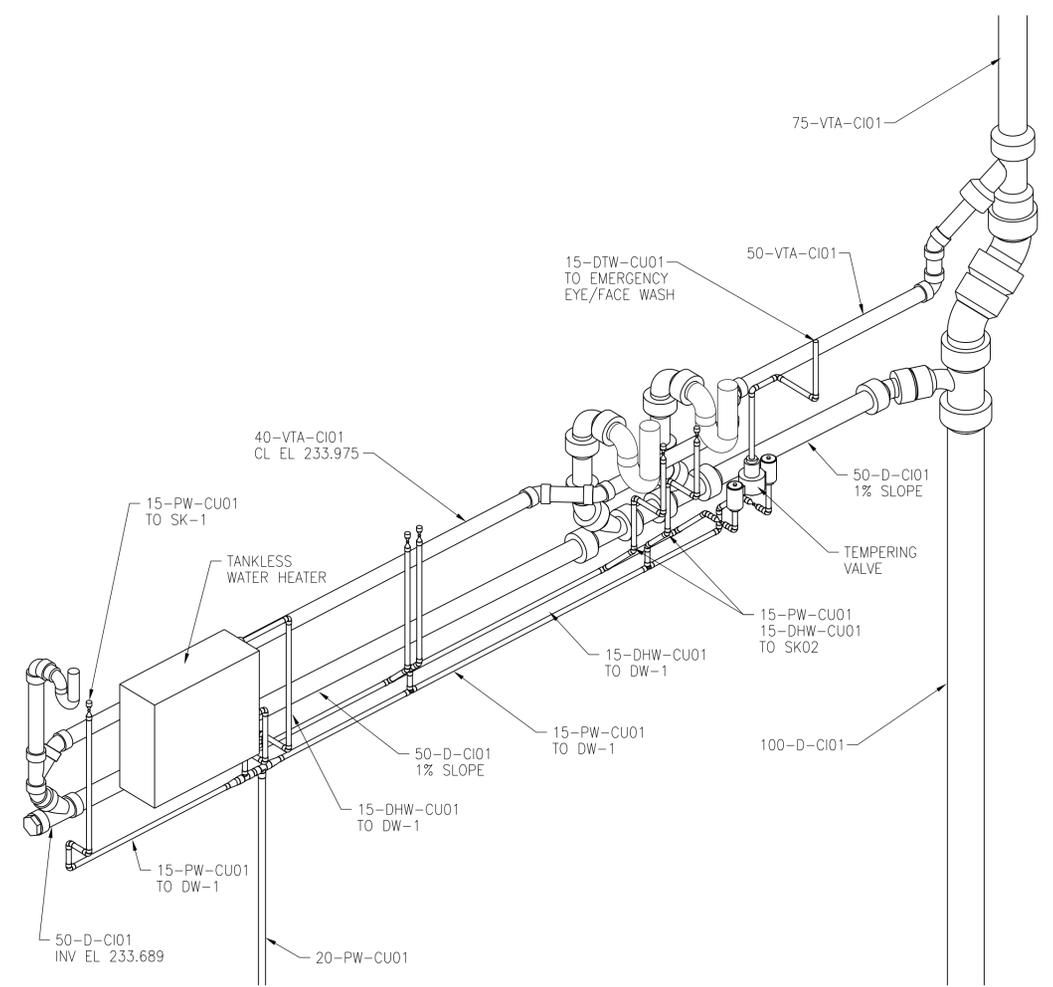

1 DETAIL
NTS
MGAD-S505