

LIGHTING DEMOLITION NOTES: "("x")"

ALSO SEE NOTES & SPECIFICATIONS.

ALL ABANDONED CABLES TO BE REMOVED FROM PLENUM SPACES AS REQUIRED BY LATEST CANADIAN ELECTRICAL CODE. DO NOT DISTURB OR DISCONNECT ANY WIRING & CABLING IN AREA OF WORK REQUIRED FOR OTHER AREAS.


1. REPLACE WITH NEW 347V LUMINAIRE, SEE RENOVATION NOTES.

2. RELOCATE LUMINAIRE, AS SHOWN. IN RENOVATION.

3. REMOVE PENDANT LUMINAIRES FROM CIRCUIT.

LUMINAIRE, SWITCH & LIGHTING CONTROL SCHEDULE				
TYPE	MANUFACTURER	CATALOGUE No.	LAMP	DESCRIPTION
4F-9 A	EXIST		(4) T8, 32W, 4100K	2'X4' RECESSED FLUORESCENT TROFFER, ACRYLIC DIFFUSER, MVOLT, ELECTRONIC BALLAST, INSTANT START RELAMP
B 4F-7	(EXIST) LIGHTOLIER	1046CL	A-19	5 1/4" APERTURE RECESSED DOWNLIGHT, SPECULAR CLEAR ALZAK, 120V PROVIDE ADJUSTABLE MOUNTING BRACKET & RELAMP, SEE RENOVATION NOTE.
347V C	LITHONIA	2GT8 4 32 A12125 347 GEB10IS LP741 CSA	(4) T8, 32W, 4100K	2'X4' RECESSED FLUORESCENT TROFFER, ACRYLIC DIFFUSER, 347V, ELECTRONIC BALLAST, INSTANT START
⇒ DIM	LUTRON MAESTRO C-L	MACL-153M		SINGLE-POLE/3WAY/MULTI-LOCATION DIMMER, 150W CFL/LED OR 600W INC/HALOGEN 120V, WHITE
347V EXIT	BEGHELLI STELLA	SL-E-12-36-L-R-1-W-2SR-5W	LED	STEEL LED EXIT SIGN WITH LED TWO-HEAD, SINGLE FACE, INPUT 120/347V, OUTPUT 12V.

ALL NEW LIGHTING LUMINAIRES AND COMPONENTS SHALL BE MANITOBA HYDRO POWER SMART APPROVED.

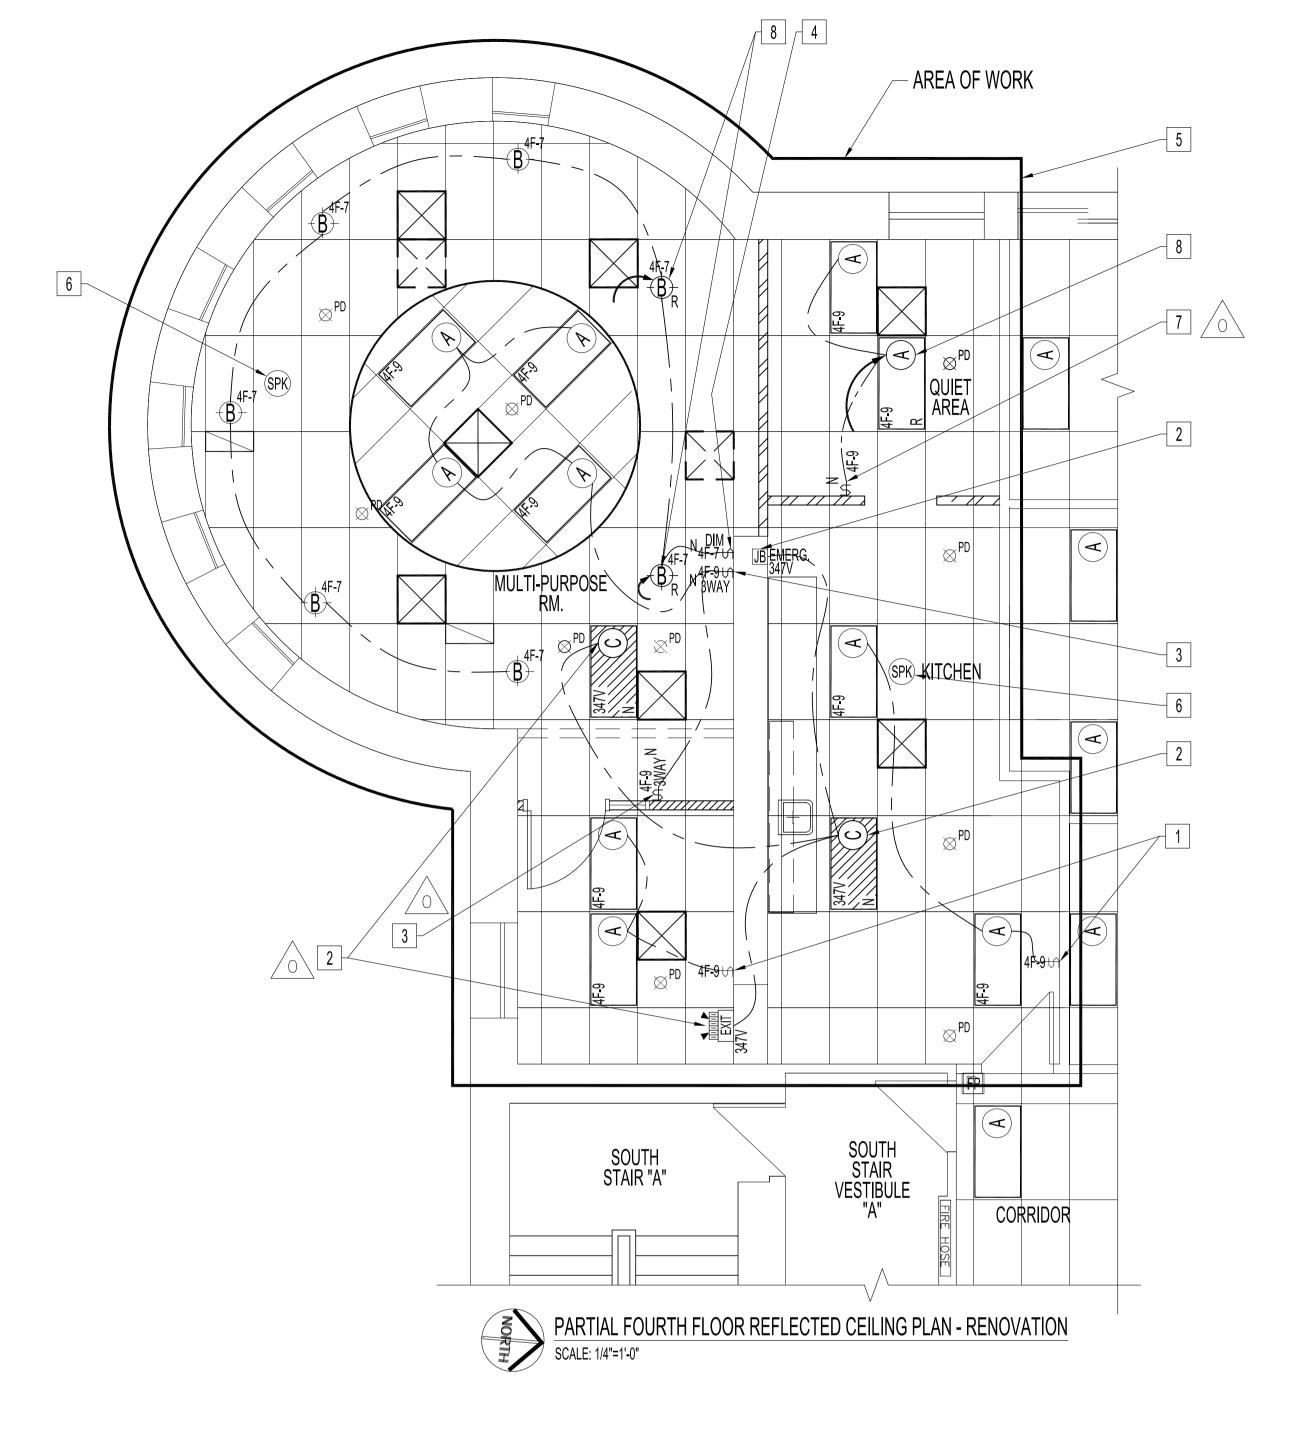

LIGHTING & PUBLIC ADDRESS RENOVATION NOTES: "["x"]"

ALSO SEE NOTES & SPECIFICATIONS.
ALL DEVICE BOXES, WIRING & CABLING SHALL BE CONCEALED IN WALL CAVITIES IN

ALL WIRING & CABLING IN CEILING SPACE SHALL BE PLENUM RATED AS PER LATEST CEC.

1. REWIRE LIGHTING CIRCUIT AS SHOWN & REPLACE LIGHT SWITCH TO DECORA STYLE.

2. CONFIRM WALL JUNCTION BOX IS 347V & CONNECTED TO BUILDING NIGHTLIGHT & EMERGENCY CIRCUIT. PROVIDE LUMINAIRES, COMBO EXIT SIGN & WIRE TO EXISTING WALL JUNCTION BOX, AS SHOWN.

3. PROVIDE 3-WAY DECORA STYLE SWITCHES & WIRE TO EXISTING LUMINAIRES SHOWN.


4. REPLACE DIMMER SWITCH & WIRE TO EXISTING LUMINAIRES AS SHOWN. RELAMP EXISTING RECESSED DOWNLIGHTS WITH LED DIMMABLE A19, 8.5W, 3500K. PROVIDE ADJUSTABLE MOUNTING BRACKETS FOR RECESSED DOWNLIGHTS FOR A SECURE

5. RELAMP AREA OF WORK & REPAIR NON-WORKING LUMINAIRES. CLEAN ALL LUMINAIRE DIFFUSER & REPLACE DAMAGE DIFFUSERS.

6. PROVIDE CEILING-MOUNT PUBLIC ADDRESS SPEAKER WITH MOUNTING FRAME. WIRE TO EXISTING CIRCUIT. TYPE TO BE SAME AS EXISTING.

7. PROVIDE DECORA STYLE SWITCH & REWIRE LIGHTING CIRCUIT AS SHOWN.

8. RELOCATE LUMINAIRE, AS SHOWN.

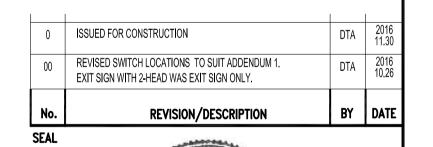

DESIGNED APPROVED CHECKED

DATE 2016.10.11 USER APPROVAL



NOTES:

REFER TO DRAWING SHEET E1.

PLANNING, PROPERTY AND DEVELOPMENT DEPARTMENT MUNICIPAL ACCOMMODATIONS DIVISION 3-65 GARRY STREET, R3C 4K4

THE CITY OF WINNIPEG

PROJECT FORT GARRY PLACE

DESIGN OF MULTI-PURPOSE ROOM AND WORKSTATIONS

65 GARRY STREET, 4TH FLOOR

SHEET TITLE

SCALE

PARTIAL FOURTH FLOOR REFLECTED CEILING PLAN LIGHTING AND PUBLIC ADDRES

BID OPP: 1081-2016

SHEET No:

DEMOLITION AND RENOVATION

2016-169 AS SHOWN

PROJECT No:

DRAWING SHEET SIZE: A1 (841mm x 594mm) PLOT 1:1