


GROUND CONDUCTOR SPLICE NTS

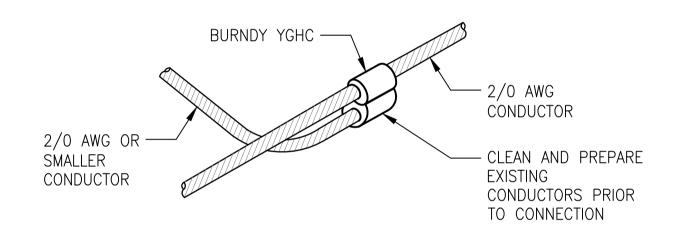



GENERAL NOTES

 THE GROUNDING RISER DIAGRAM REPRESENTS THE MINIMUM GROUNDING AND BONDING REQUIREMENTS. PROVIDE ADDITIONAL GROUNDING AND BONDING AS REQUIRED TO MEET CEC REQUIREMENTS.

Certificate of Authorization
SNC-Lavalin Inc.
No. 4489

NO. REVISIONS

					SNC·LAVALIN	SNC-LAVALIN INC. 148 Nature Park Way Winnipeg, MB, Canada R3P 0X7 204-786-8080	ENGINEER'S SEAL ORIGINAL DRAWING
					DESIGNED BY: B. CLEVEN	CHECKED BY: D. BECKER	SEALED BY: B. J. CLEVEN SNC-LAVALIN INC. MEMBER # 31479 2016-08-29 REV. 00
					DRAWN BY: Y. KONIG	APPROVED BY: I. PARKINSON	
					scale: NTS	ISSUED FOR CONSTRUCTION BY: K. ZUREK	
	00	ISSUED FOR TENDER, BID OPP. 767-2016	2016/08/23	BJC	DATE: 2016/06/10	DATE: 2016-08-29	

DATE DESIGN CHECK

RIGINAL DRAWING
SEALED BY:
B. J. CLEVEN
NC-LAVALIN INC.

THE CITY OF WINNIPEG

WATER AND WASTE DEPARTMENT

ROUTE 90 UNDERPASS PUMPING STATION
2016 UPGRADES
GROUNDING INSTALLATION DETAILS

CITY DRAWING NUMBER SHEET REV. SIZE 1-0310U-E0003 001 00 A1

1-0310U-E0003-001-00.dwg