

4TH FLOOR - 185 KING STREET R3B 1J1 Project:

St. Vital Library

_	6 Fermor Ave. Winnipeg Manitoba	a
_	Project Number:	16054
	Bid Opportunity Number:	768-2016
	Drawing Title: NEW MAIN FLOOR POW	ER PLAN


Issue/Revision Date ISSUED FOR CONSTRUCTION

APEGIN Certificate of Authorization Sheet No: E-11

HDK Consulting Incorporated

No. 5539 Date: 04/30/2017

This drawing is property of the Architect and cannot be reproduced or used without the consent of the Architect. The contractor is responsible for checking and verifying all levels and dimensions and shall report all discrepancies to the Architect and obtain clarification prior to commencing work.

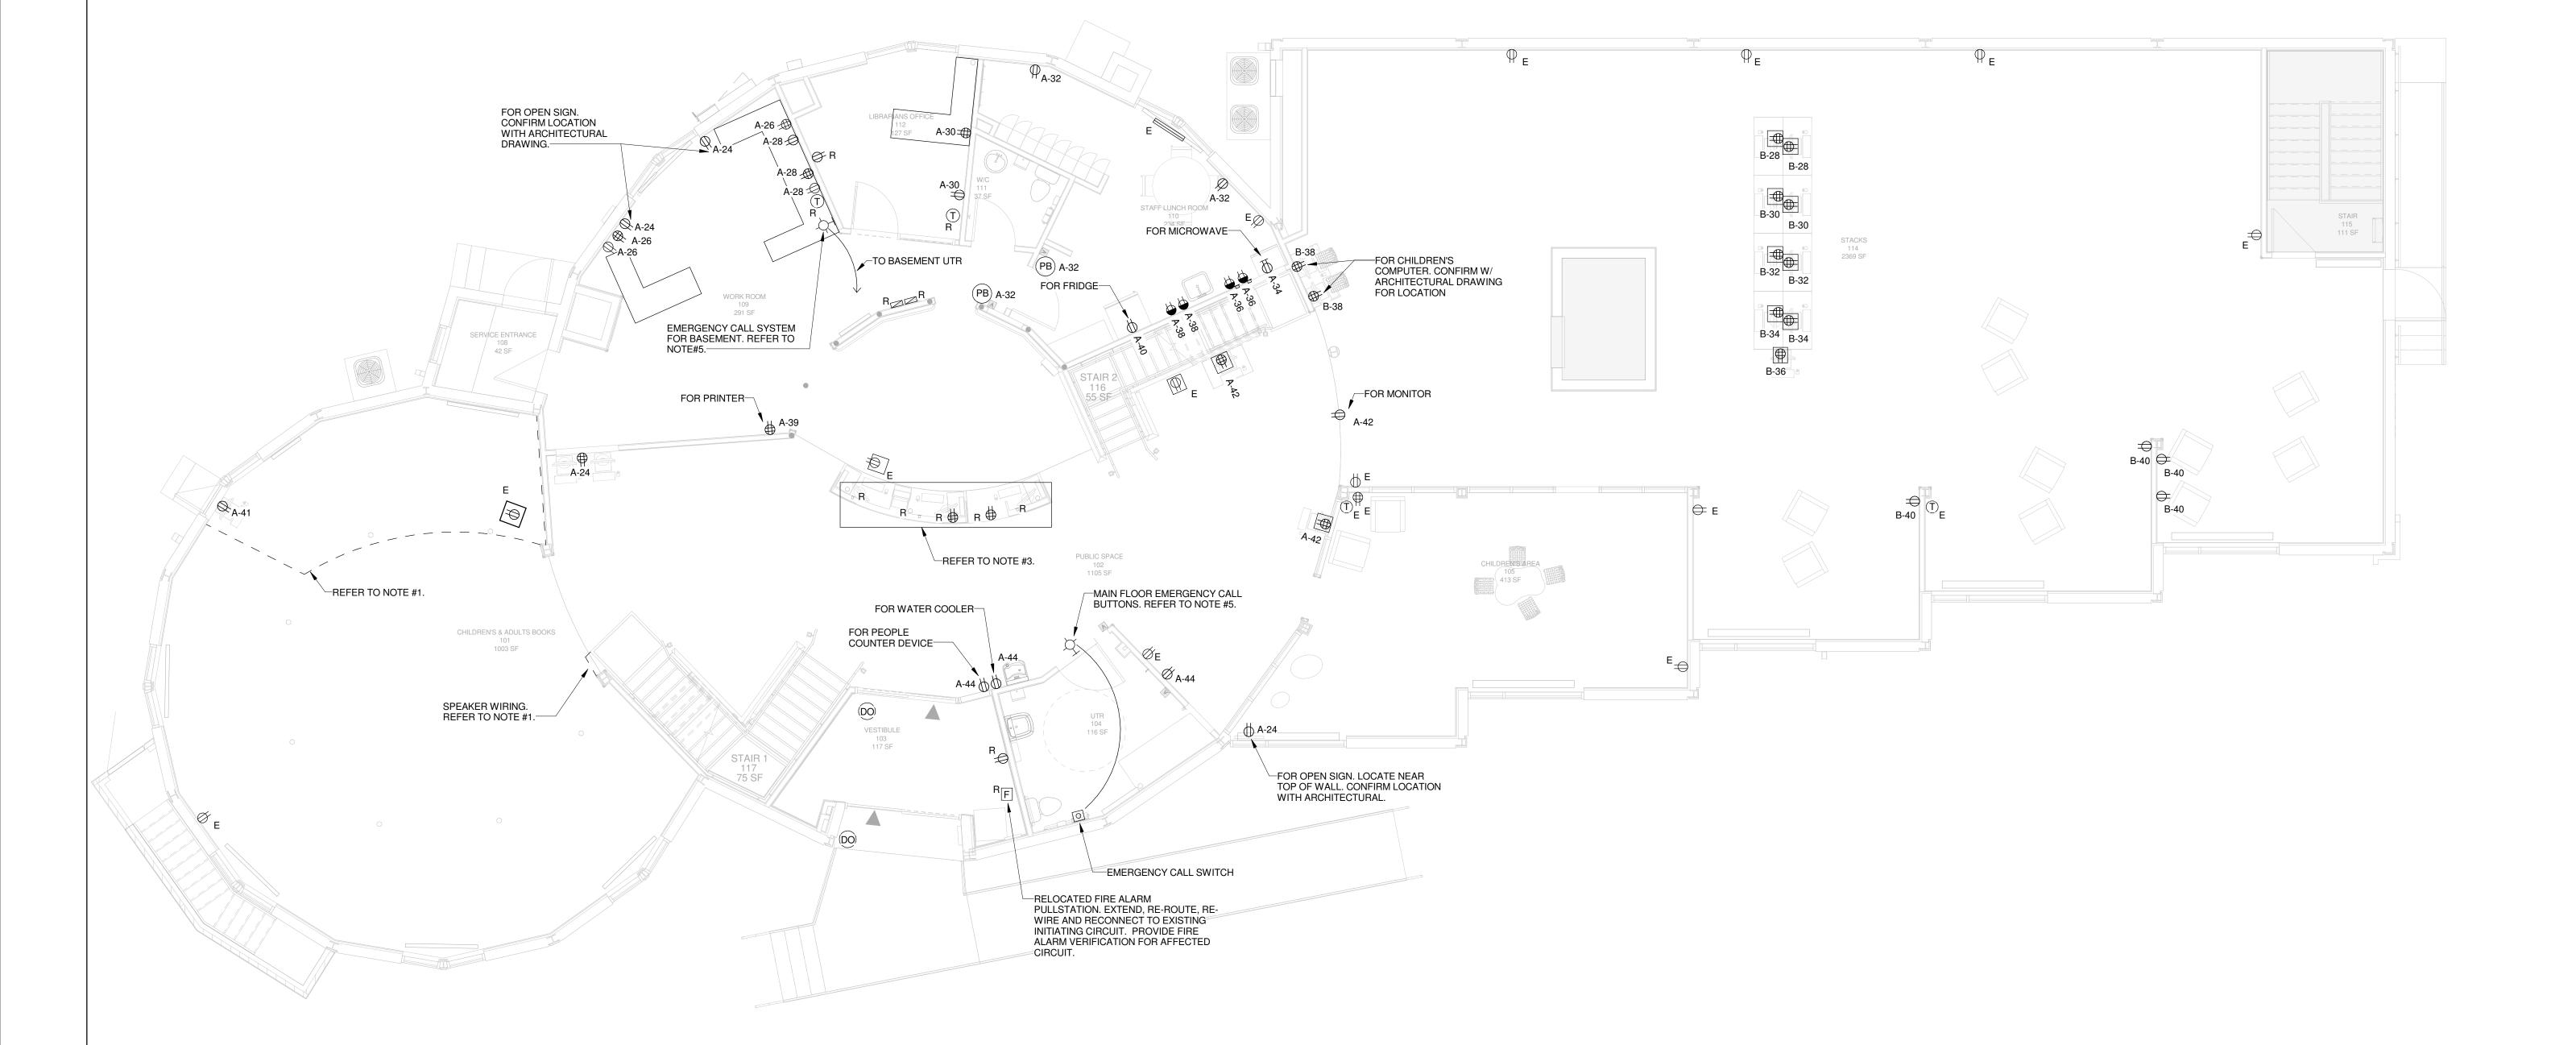

NEW MAIN FLOOR POWER PLAN

NOTES:

- 1. EXISTING WIRING TO BE CONCEALED BEHIND WALL/CEILING.
- 2. REPLACE ALL EXISTING RECEPTACLES TO TEMPER RESSISTANCE DECORA TYPE.
- RELOCATE RECEPTACLES. EXTEND RE-ROUTE, RE WIRE AND RECONNECT TO EXISTING ON SITE. FINAL LOCATION TO BE COORDINATED ON SITE. REFER TO ARCHITECTURAL DRAWINGS FOR DETAILS.
- 4. REFER TO ARCHITECTURAL DRAWINGS FOR DOOR ACTUATOR LOCATION.
- PROVIDE AND INSTALL SEPARATE EMERGENCY CALL ALARM AND SIGNAL DEVICES FOR BASEMENT AND MAIN FLOOR UNIVERSAL TOILET ROOM. MANUFACTURED BY FEDERAL SIGNAL, MODEL #USIS C/W BUILT-IN SOUNDER.