THE CITY OF WINNIPEG PLANNING, PROPERTY AND DEVELOPMENT DEPARTMENT MUNICIPAL ACCOMMODATIONS DIVISION 4TH FLOOR - 185 KING STREET R3B 1J1

Project: St. Vital Library

> 6 Fermor Ave. Winnipeg Manitoba Project Number: Bid Opportunity Number: Drawing Title: EXISTING MAIN FLOOR LIGHTING & EMERGENCY LIGHTING PLAN

Issue/Revision Date ISSUED FOR CONSTRUCTION

Sheet No: E-3

This drawing is property of the Architect and cannot be reproduced or used without the consent of the Architect. The contractor is responsible for checking and verifying all levels and dimensions and shall report all discrepancies to the Architect and obtain clarification prior to commencing work.


APEGM Certificate of Authorization

HDK Consulting Incorporated







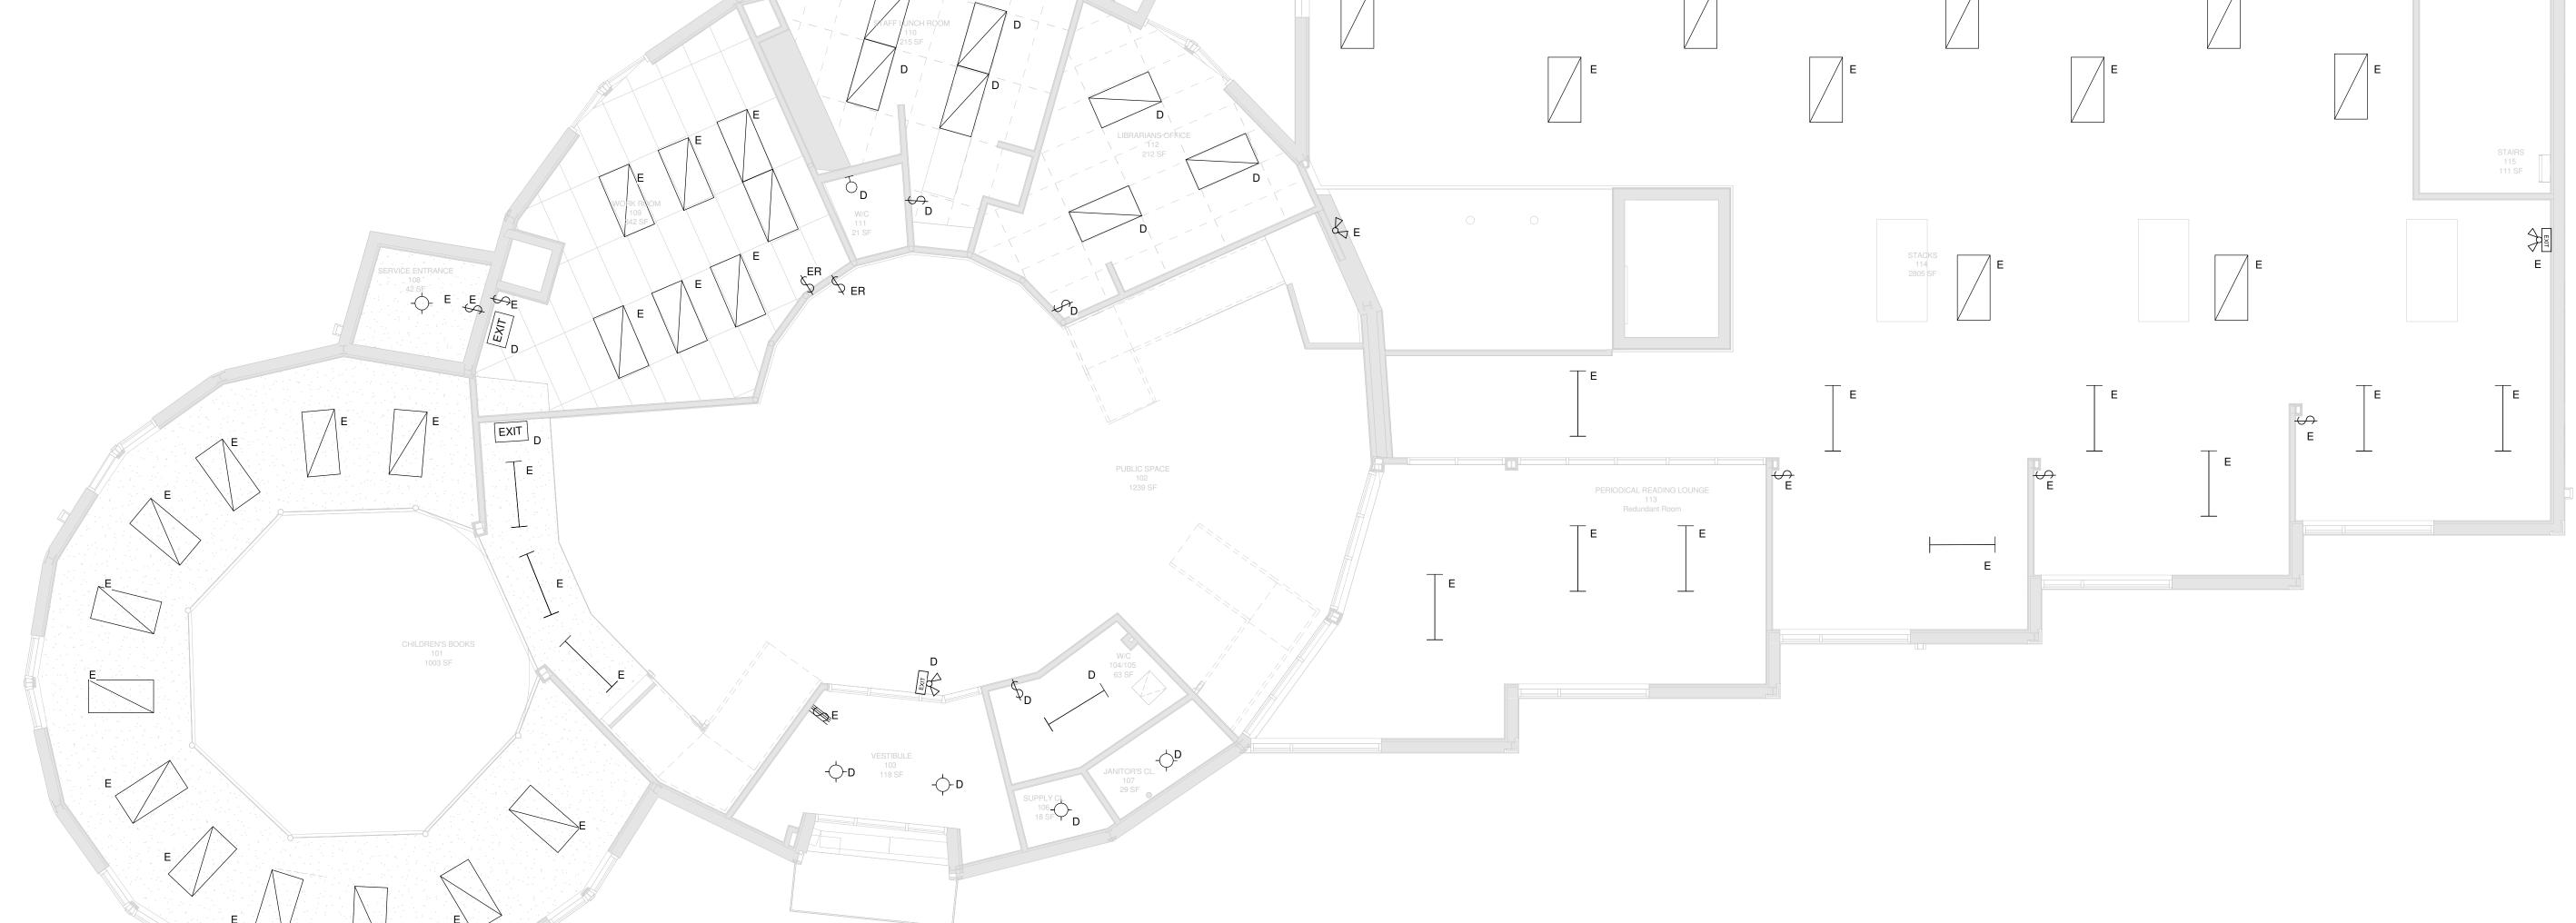

EXISTING MAIN FLOOR LIGHTING & EMERGENCY LIGHTING PLAN

3/16" = 1'-0"

- 1. MAINTAIN THE INTEGRITY OF ALL SYSTEMS IN AREAS INCLUDED AND NOT INCLUDED IN THIS PROJECT. IDENTIFY BREAKERS, WIRING, LIGHTING, FIRE ALARM SYSTEMS IN GENERAL AND JUNCTION BOXES BEFORE PROCEEDING WITH WORK. CONTACT CONTRACT ADMINISTRATOR IF UNSURE BEFORE ANY ACTION OF RELOCATION, DEMOLITION OR INTERRUPTION OF SERVICES.
- 2. ALL ITEMS SHOWN DOTTED ARE EXISTING AND SHALL REMAIN OR BE RELOCATED AS NOTED. ITEMS MARKED WITH A (D) SHALL BE DISCONNECTED, REMOVED AND DEMOLISHED. ALL DEMOLISHED DEVICES TO HAVE ASSOCIATED WIRING AND CONDUIT REMOVED BACK TO
- 3. WIRING AND CONDUIT REQUIRED TO REMAIN IN USE FOR ANY REASON SHALL BE RE-ROUTED, ALTERED AND/OR DIVERTED IN AN APPROVED
- .1 ANY BRANCH CIRCUIT WIRING, OUTLET, ETC. FOR ANY SYSTEM TO REMAIN IN USE SHALL BE EXTENDED, RE-ROUTED AND RE-WIRED BACK TO NEAREST AVAILABLE ELECTRICAL PANEL. PROVIDE CIRCUIT BREAKERS TO SUIT. CONFIRM EXISTING ON SITE.
- .2 ANY BRANCH CIRCUIT WIRING, OUTLET, ETC. FOR ANY SYSTEM NO LONGER REQUIRED TO REMAIN IN USE SHALL BE REMOVED, OR IF THIS IS NOT POSSIBLE RENDÉRED PERMANENTLY INACCESSIBLE AND COMPLETELY DISCONNECTED FROM PANEL.
- 4. NOT ALL EXISTING EQUIPMENT OR DEVICES ARE SHOWN ON ELECTRICAL DRAWINGS. ELECTRICAL CONTRACTOR TO REMOVE OR
- RELOCATE EXISTING ELECTRICAL DEVICES AS SHOWN ON ELECTRICAL OR MECHANICAL DRAWINGS. 5. FIRE ALARM SYSTEM TO BE OPERATIONAL AT ALL TIMES. INTERRUPTIONS FOR CIRCUITS MODIFICATIONS ARE TO BE COORDINATED WITH
- 6. BUILDING IS TO REMAIN IN NORMAL OPERATION DURING DURING ELECTRICAL DEMOLITION. ELECTRICAL WORK SHALL NOT ACCIDENTALLY
- DISRUPT SYSTEMS IN OTHER AREAS OF THE BUILDING. OBTAIN WRITTEN AUTHORIZATION NOTE FROM MANAGEMENT PREVIOUS TO ANY SHUTDOWN.
- 7. PROVIDE BLANK STAINLESS STEEL COVER PLATES FOR ALL ABANDONED OUTLETS.

BUILDING MANAGEMENT. CONFIRM EQUIPMENT INTERLOCKS BEFORE PROCEEDING WITH WORK.

- 8. ALL EXISTING LIGHT SWITCHES TO BE LOWERED TO 1000mm AFF. EXTEND, RE-ROUTE, RE-WIRE AND RECONNECT AS REQUIRED. CONFIRM EXISTING ON SITE.
- 9. NOT ALL EXISTING EQUIPMENT OR DEVICES ARE SHOWN ON ELECTRICAL DRAWINGS. REMOVE OR RELOCATE EXISTING DEVICES CONFLICTING WITH WALLS THAT ARE BEING DEMOLISHED, MODIFIED OR RENOVATED.