

THE CITY OF WINNIPEG PLANNING, PROPERTY AND DEVELOPMENT DEPARTMENT MUNICIPAL ACCOMMODATIONS DIVISION 4TH FLOOR - 185 KING STREET R3B 1J1


Project: St. Vital Library

6 Fermor Ave. Winnipeg Manitoba Project Number: 16054 Bid Opportunity Number: 768-2016 Drawing Title: EXISTING MAIN FLOOR POWER PLAN

Issue/Revision Date ISSUED FOR CONSTRUCTION

Sheet No: E-6

This drawing is property of the Architect and cannot be reproduced or used without the consent of the Architect. The contractor is responsible for checking and verifying all levels and dimensions and shall report all discrepancies to the Architect and obtain clarification prior to commencing work.

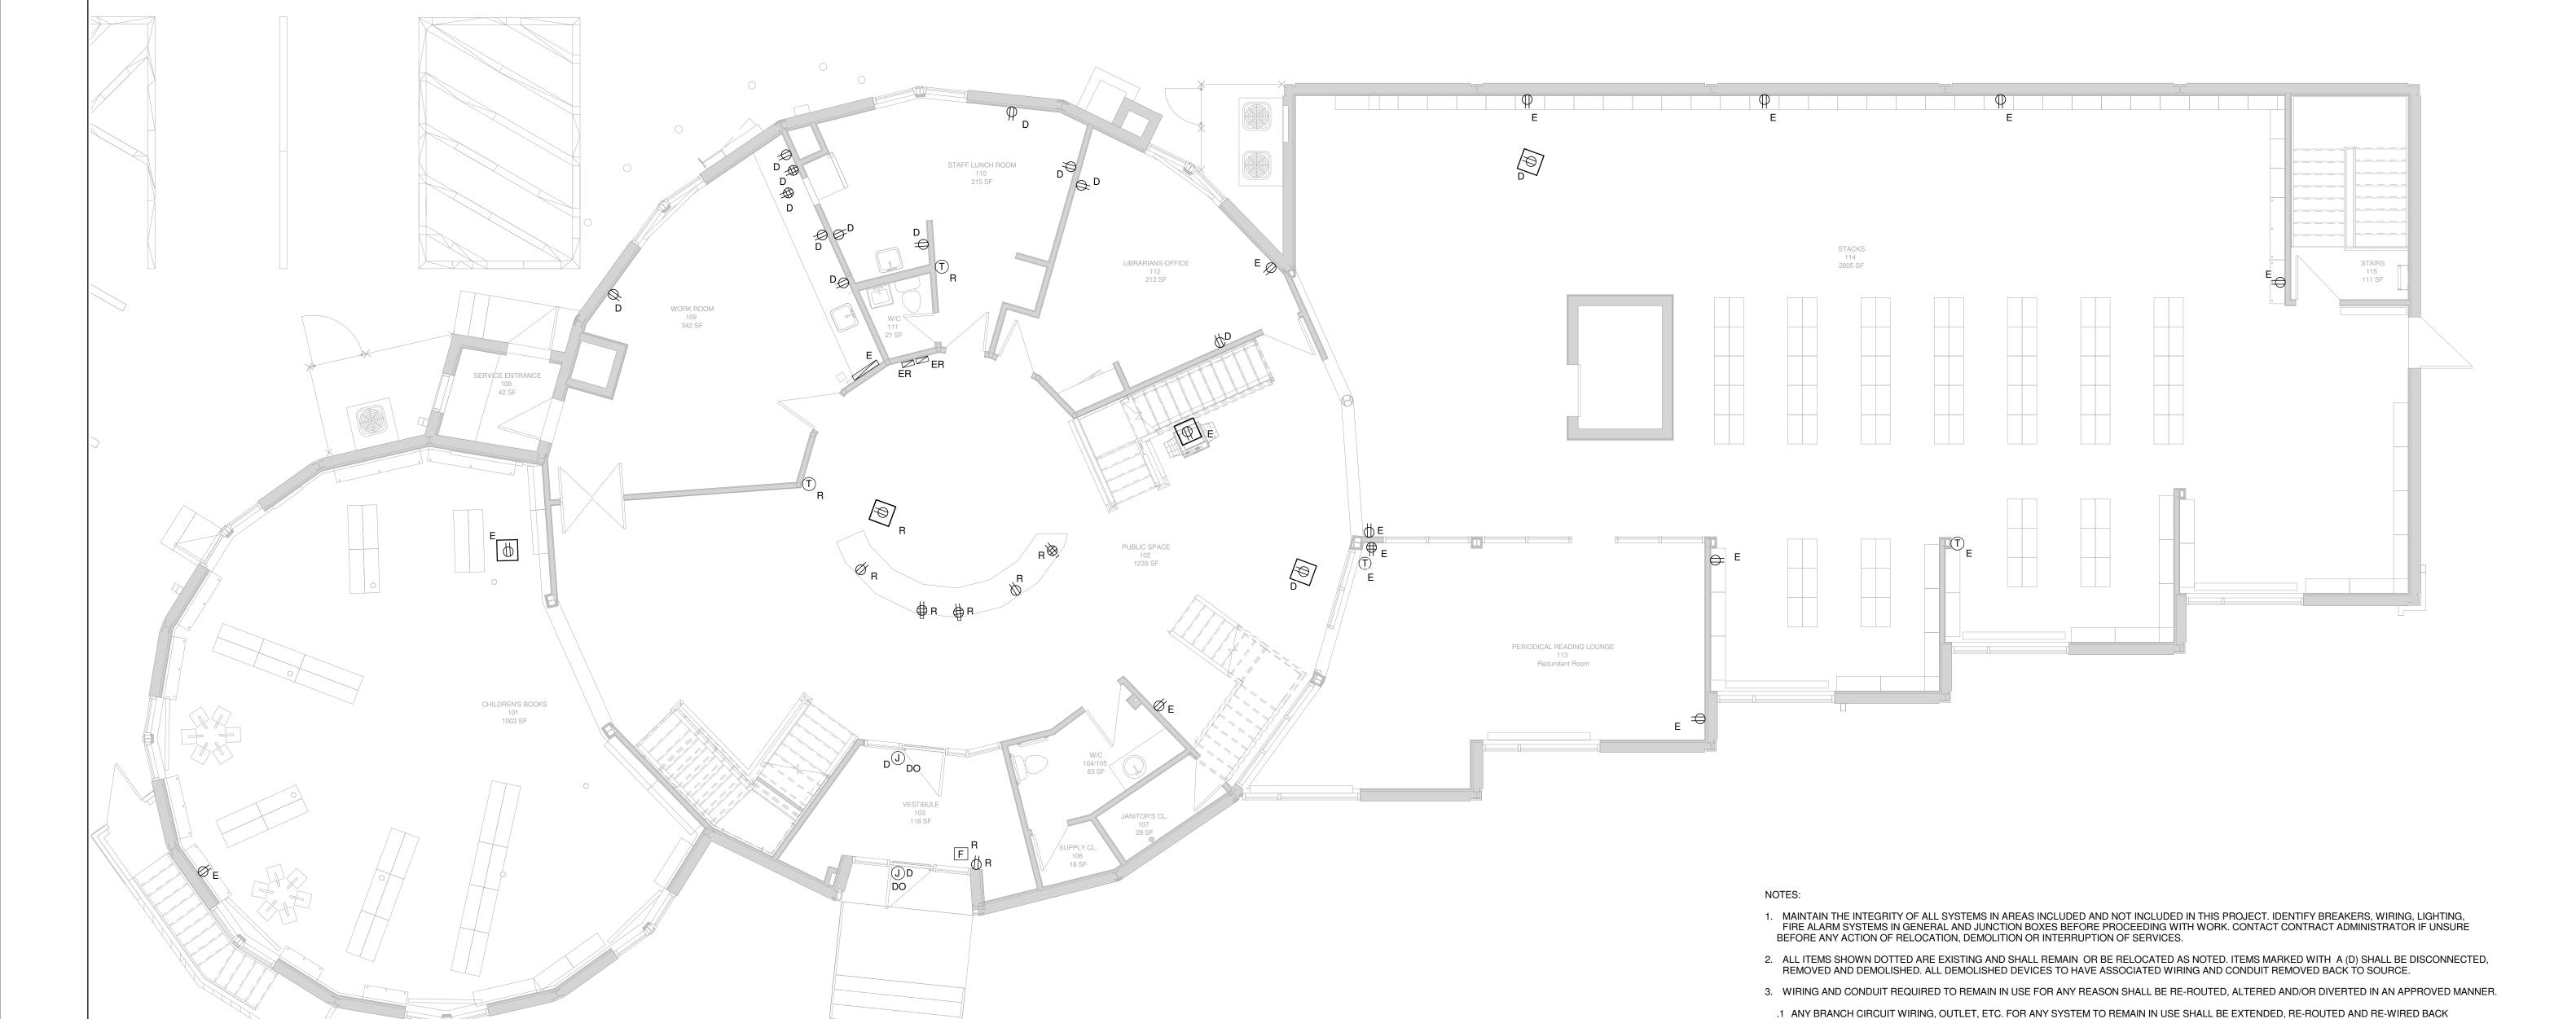

EXISTING MAIN FLOOR POWER PLAN



APEGIN

Certificate of Authorization

HDK Consulting Incorporated

No. 5539 Date: 04/30/2017

TO NEAREST AVAILABLE ELECTRICAL PANEL. PROVIDE CIRCUIT BREAKERS TO SUIT. CONFIRM EXISTING ON SITE.

POSSIBLE RENDERED PERMANENTLY INACCESSIBLE AND COMPLETELY DISCONNECTED FROM PANEL.

EXISTING ELECTRICAL DEVICES AS SHOWN ON ELECTRICAL OR MECHANICAL DRAWINGS.

MANAGEMENT. CONFIRM EQUIPMENT INTERLOCKS BEFORE PROCEEDING WITH WORK.

7. PROVIDE BLANK STAINLESS STEEL COVER PLATES FOR ALL ABANDONED OUTLETS.

WALLS THAT ARE BEING DEMOLISHED, MODIFIED OR RENOVATED.

.2 ANY BRANCH CIRCUIT WIRING, OUTLET, ETC. FOR ANY SYSTEM NO LONGER REQUIRED TO REMAIN IN USE SHALL BE REMOVED, OR IF THIS IS NOT

5. FIRE ALARM SYSTEM TO BE OPERATIONAL AT ALL TIMES. INTERRUPTIONS FOR CIRCUITS MODIFICATIONS ARE TO BE COORDINATED WITH BUILDING

6. BUILDING IS TO REMAIN IN NORMAL OPERATION DURING DURING ELECTRICAL DEMOLITION. ELECTRICAL WORK SHALL NOT ACCIDENTALLY DISRUPT

8. NOT ALL EXISTING EQUIPMENT OR DEVICES ARE SHOWN ON ELECTRICAL DRAWINGS. REMOVE OR RELOCATE EXISTING DEVICES CONFLICTING WITH

4. NOT ALL EXISTING EQUIPMENT OR DEVICES ARE SHOWN ON ELECTRICAL DRAWINGS. ELECTRICAL CONTRACTOR TO REMOVE OR RELOCATE

SYSTEMS IN OTHER AREAS OF THE BUILDING. OBTAIN WRITTEN AUTHORIZATION NOTE FROM MANAGEMENT PREVIOUS TO ANY SHUTDOWN.