


DEMOLITION - BUILDING FLOOR PLAN  
SCALE 1:20

NOTES

- 1) REMOVE ALL ELECTRICAL EQUIPMENT AND MATERIALS INCLUDING, BUT NOT LIMITED TO:

LIGHTING  
PANELBOARDS  
GENERATOR  
CABLING AND CONDUITS  
CONTROL PANELS

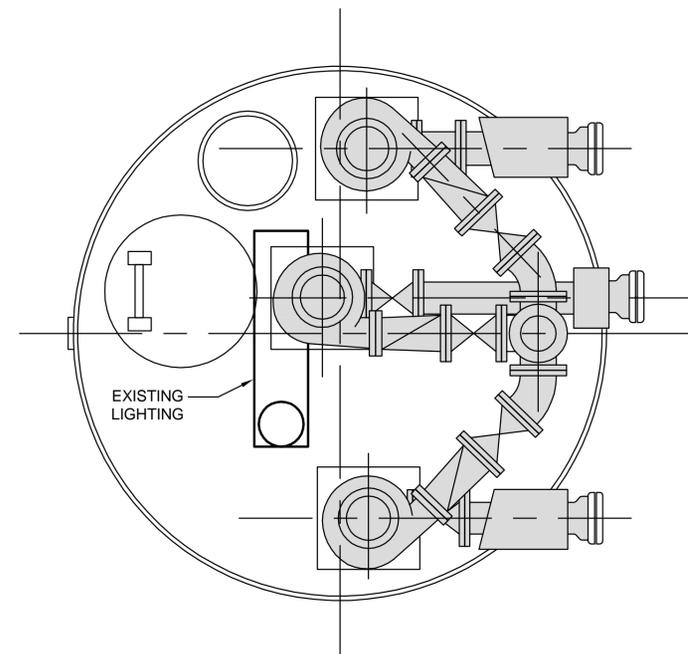

STATION FLOOR PLAN  
SCALE 1:20



B.M. ELEV.	DESIGNED BY	BLM
	DRAWN BY	SCK
	CHECKED BY	BLM
	APPROVED BY	
	HOR. SCALE	AS SHOWN
	VERTICAL	
0 ISSUED FOR BID OP. 803-2016	16/09/14	BLM
NO. REVISIONS	DATE	BY DATE

**DILLON CONSULTING**

RELEASED FOR CONSTRUCTION

DATE

PROVINCE OF MANITOBA  
B.L. MOORE  
Sept. 14/16  
REGISTERED PROFESSIONAL ENGINEER

CONSULTANT PROJECT NO.  
163523

**THE CITY OF WINNIPEG**  
WATER AND WASTE DEPARTMENT

**BURROWS WASTEWATER PUMPING STATION UPGRADES ELECTRICAL - DEMOLITION**

CITY DRAWING NUMBER  
1-01211-E0002-001

SHEET 9 OF 16

E-1