


BUILDING FLOOR PLAN
SCALE 1:20



STATION FLOOR PLAN
SCALE 1:20

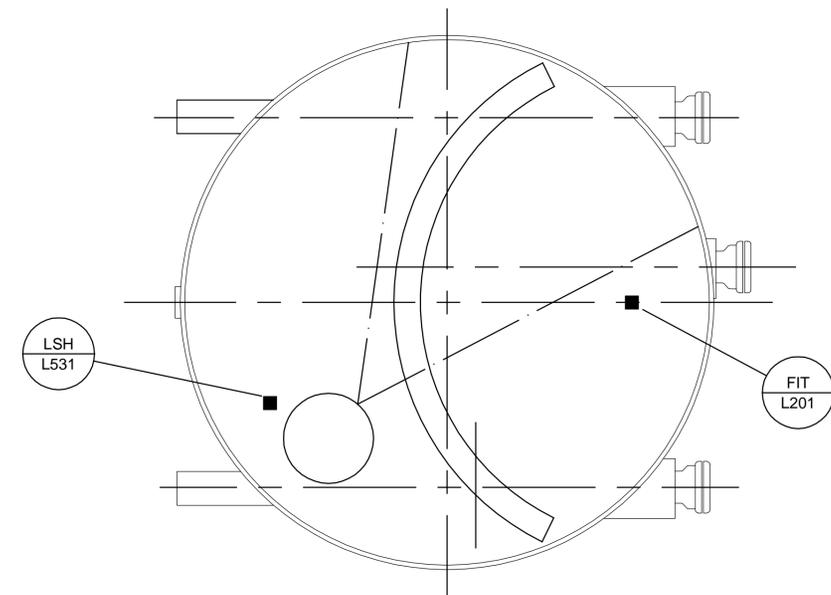

B.M. ELEV.	DESIGNED BY	BLM
	DRAWN BY	SCK
	CHECKED BY	BLM
	APPROVED BY	
	HOR. SCALE	AS SHOWN
	VERTICAL	
A	ISSUED FOR BID OP. 803-2016	16/09/14 BLM
NO.	REVISIONS	DATE BY DATE

DILLON CONSULTING

RELEASED FOR CONSTRUCTION

DATE

PROVINCE OF MANITOBA
B.L. MOORE
Sept. 14/16
REGISTERED PROFESSIONAL ENGINEER

CONSULTANT PROJECT NO.
163523

THE CITY OF WINNIPEG
WATER AND WASTE DEPARTMENT

BURROWS WASTEWATER PUMPING STATION UPGRADES FLOOR PLANS - INSTRUMENTATION

CITY DRAWING NUMBER
1-0121L-E0005-001

SHEET 12 OF 16

E-4