


BUILDING SOUTH SECTION
SCALE 1:20

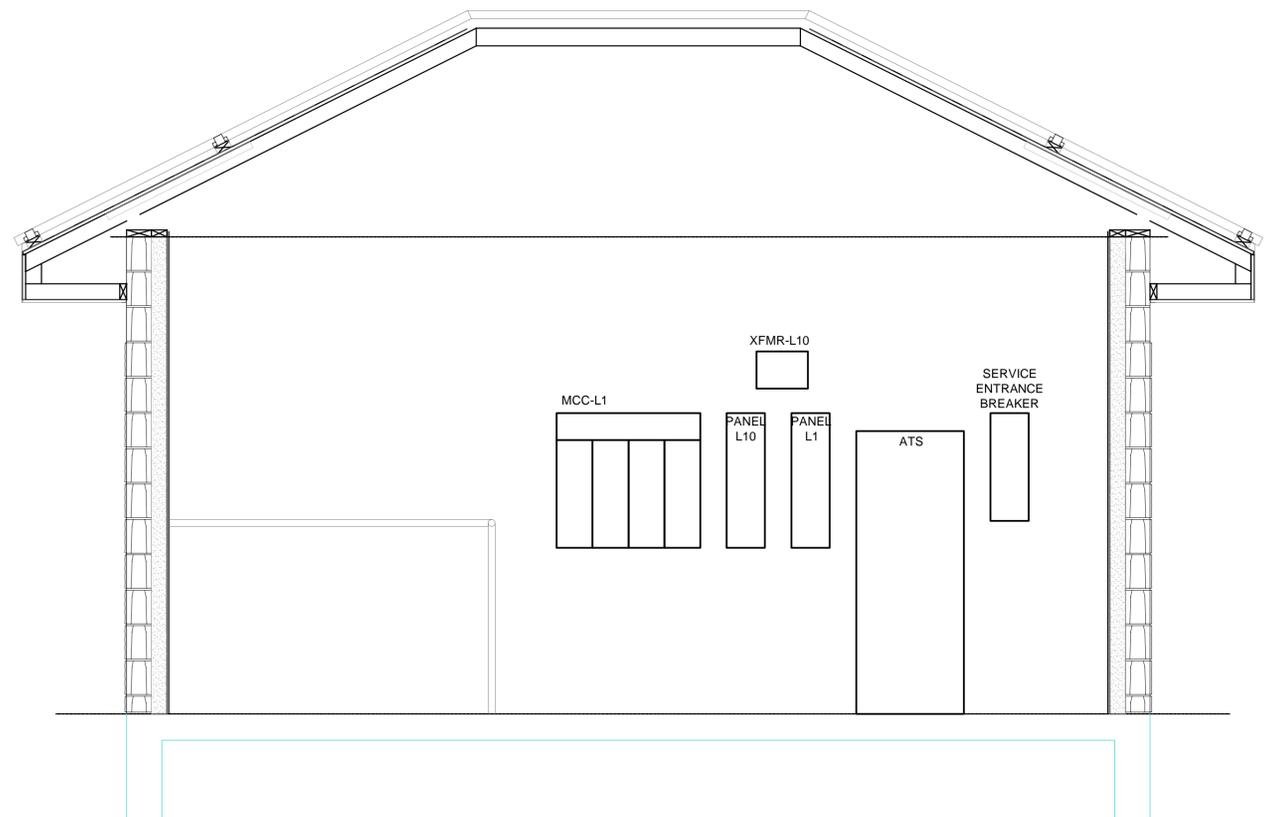

BUILDING EAST SECTION
SCALE 1:20



B.M. ELEV.		DESIGNED BY BLM	 DILLON CONSULTING		 THE CITY OF WINNIPEG WATER AND WASTE DEPARTMENT	BURROWS WASTEWATER PUMPING STATION UPGRADES ELECTRICAL DETAILS	CITY DRAWING NUMBER 1-0121L-E0006-001
		DRAWN BY SCK					SHEET 13 OF 16
		CHECKED BY BLM					
		APPROVED BY					
		HOR. SCALE AS SHOWN	RELEASED FOR CONSTRUCTION	CONSULTANT PROJECT NO. 163523			E-5
		VERTICAL	DATE				
NO.	REVISIONS	DATE	BY	DATE			