



D SIZE 22" x 34" (559mm x 864mm)

PLOT: 2/6/2018 4:31:27 PM


AECOM REVIEW DRFT CHK AECOM FILE NAME: 60509089-SHT-30-0000-S-4003\_S-4004.dwg Saved By: cooperkl

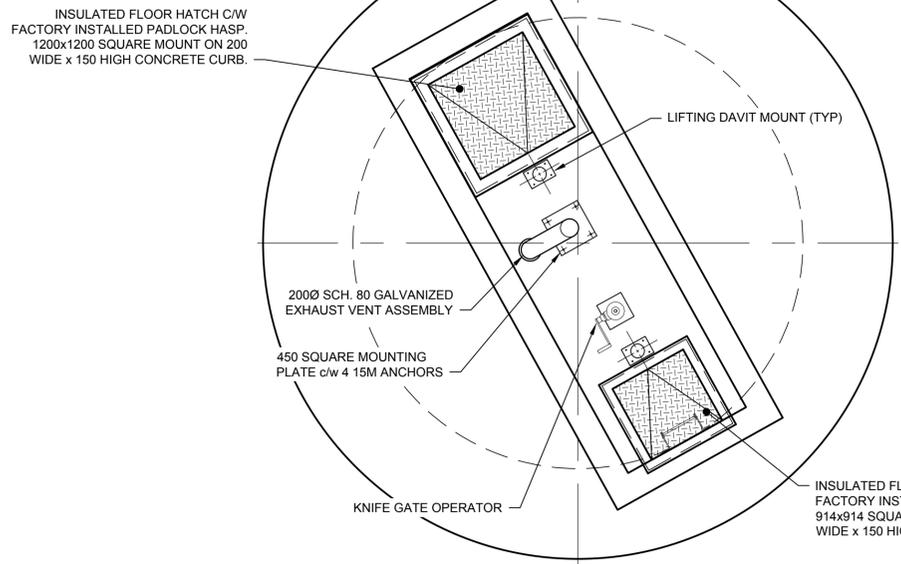

**DETAIL**  
ROOF PLAN  
EL 230.10  
0 1000 2000 mm  
1:40

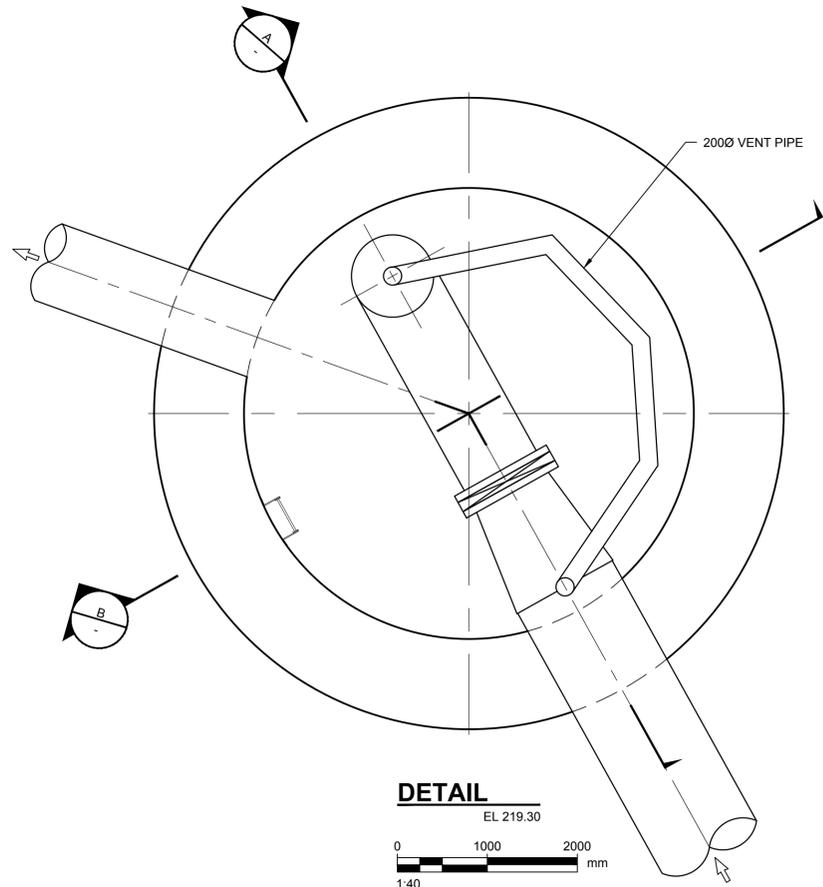

**DETAIL**  
EL 219.30  
0 1000 2000 mm  
1:40

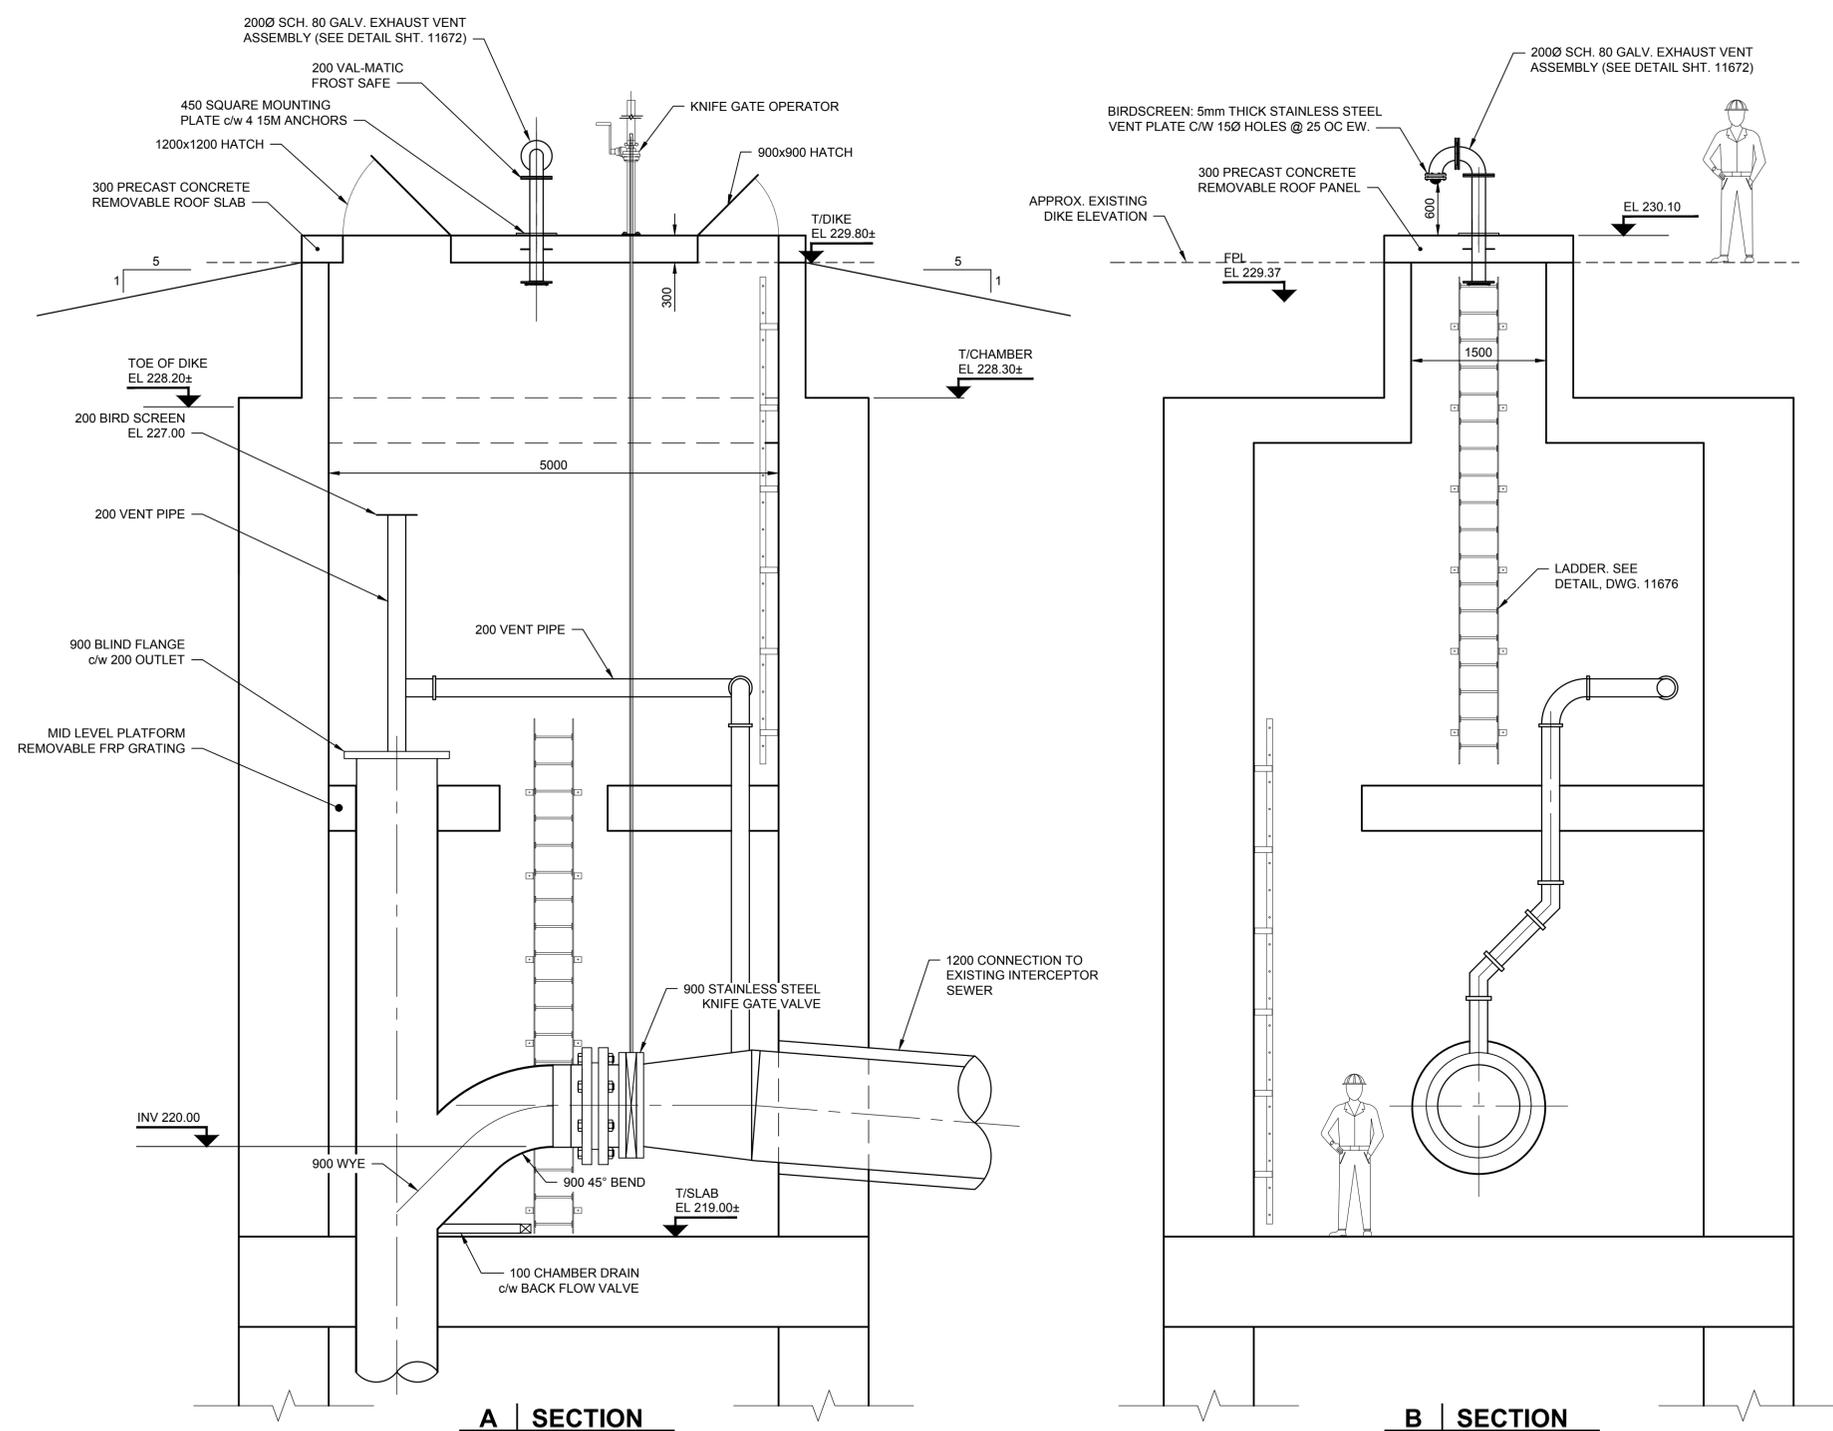

**A SECTION**  
0 1000 2000 mm  
1:40

**B SECTION**  
0 1000 2000 mm  
1:40

**PRELIMINARY**  
NOT FOR CONSTRUCTION

**LOCATION APPROVED**  
UNDERGROUND STRUCTURES

SUPR. U/G STRUCTURES COMMITTEE	DATE

**NOTE:**  
LOCATION OF UNDERGROUND STRUCTURES AS SHOWN ARE BASED ON THE BEST INFORMATION AVAILABLE. BUT NO GUARANTEE IS GIVEN THAT ALL EXISTING UTILITIES ARE SHOWN OR THAT THE GIVEN LOCATIONS ARE EXACT. CONFIRMATION OF EXISTENCE AND EXACT LOCATION OF ALL SERVICES MUST BE OBTAINED FROM THE INDIVIDUAL UTILITIES BEFORE PROCEEDING WITH CONSTRUCTION.

NO.	REVISIONS	DATE	BY
B	ISSUED FOR 50% REVIEW	18/02/05	KLC
A	ISSUED FOR 33% REVIEW	17/12/01	KLC

**AECOM**

DESIGNED BY	ADB	CHECKED BY	
DRAWN BY	ADL/KLC	APPROVED BY	
HOR. SCALE	AS NOTED	RELEASED FOR CONSTRUCTION	
VERT. SCALE	AS NOTED	DATE	

PROFESSIONAL'S SEAL

CONSULTANT DRAWING NO.  
60509089-SHT-30-0000-S-4003\_S-4004

**THE CITY OF WINNIPEG**  
WATER AND WASTE DEPARTMENT

**NORTHEAST INTERCEPTOR SEWER RIVER CROSSING**

**SIPHON INLET CHAMBER**  
PLANS, SECTIONS AND DETAILS

SHEET 08 OF 09  
CITY DRAWING NUMBER  
**11675**

BID OPPORTUNITY NO. 1136-2017B

**METRIC**  
WHOLE NUMBERS INDICATE MILLIMETRES  
DECIMALIZED NUMBERS INDICATE METRES