



FILENAME: C:\PROJECTS\WORKING_DIRECTORY\ACTIVE_40SK\04462543\175009-10-McCARTHY-ST-ELECT-SITE-PLAN.DWG PLOTTED BY: KOWALSKI, STANLEY
 PLOT DATE: 2018-01-16 @ 10:43:38 AM PLOT SCALE: 1:1.0108 PLOT STYLE: FULL-COLOR.CTB

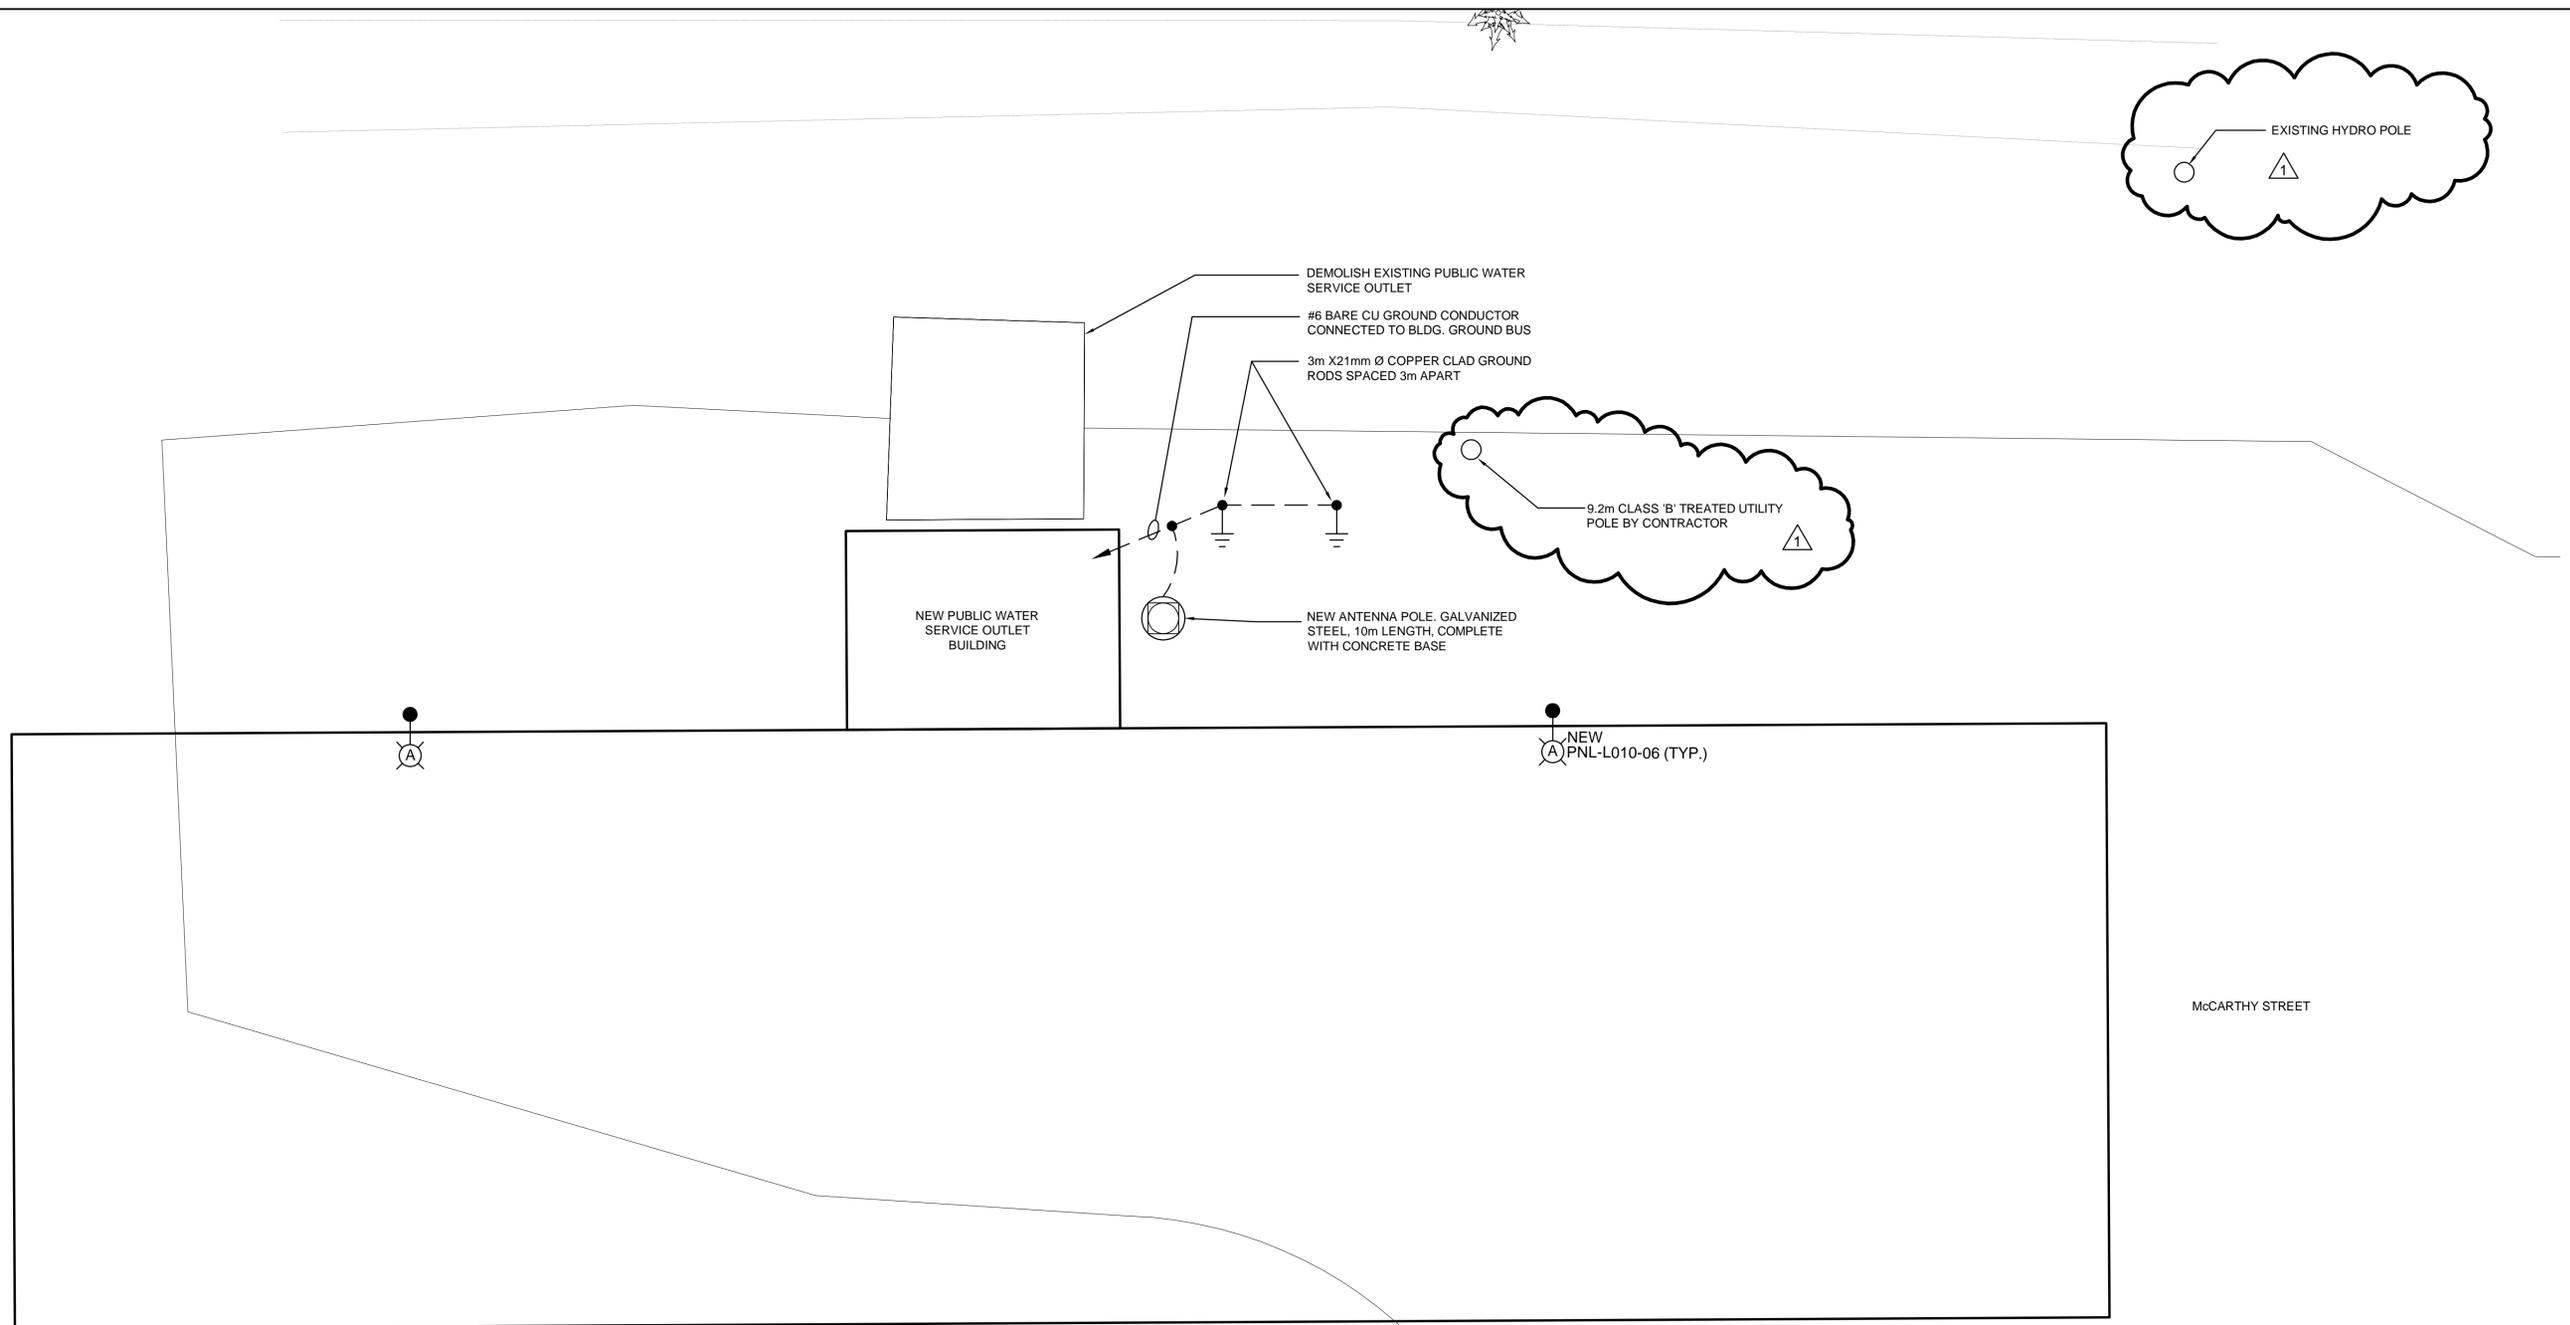

NEW LIGHT FIXTURE SCHEDULE	
	LED COBRA HEAD 25W, 120 VOLT TYPE 3 LIGHT DISTRIBUTION FULL CUTOFF 80 CRI WITH INTEGRAL PHOTOCCELL CONTROL ON 9.14m GALV. STEEL DAVIT POLE

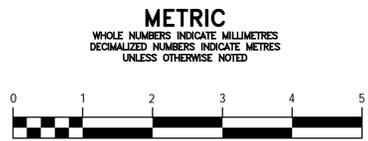

LOCATION APPROVED UNDERGROUND STRUCTURES

SUPV. U/G STRUCTURES COMMITTEE _____ DATE _____

NOTE:
 LOCATION OF UNDERGROUND STRUCTURES AS SHOWN ARE BASED ON THE BEST INFORMATION AVAILABLE BUT NO GUARANTEE IS GIVEN THAT ALL EXISTING UTILITIES ARE SHOWN OR THAT THE GIVEN LOCATIONS ARE EXACT. CONFIRMATION OF EXISTENCE AND EXACT LOCATION OF ALL SERVICES MUST BE OBTAINED FROM THE INDIVIDUAL UTILITIES BEFORE PROCEEDING WITH CONSTRUCTION.

B.M. ELEV.			
CONSTRUCTION COMPLETION DATE: YYYY MM DD			
NO.	REVISIONS	DATE	BY
1	ISSUED FOR ADDENDUM No.2	18/01/16	B.L.M.
0	ISSUED FOR BID OP 634-2017	17/11/23	B.L.M.

DESIGNED BY	B.L.M.	CHECKED BY	
DRAWN BY	E.J.H.	APPROVED BY	
SCALE:	HORIZONTAL 1:50	RELEASED FOR CONSTRUCTION	
DATE	2017 07 07	DATE	

ENGINEER'S SEAL

CONSULTANT DRAWING NUMBER
E-05

THE CITY OF WINNIPEG
 WATER AND WASTE DEPARTMENT
 ENGINEERING DIVISION

2017 REHABILITATION OF PUBLIC WATER SERVICE OUTLETS: PAVEMENT WORKS, BUILDING SUPPLY AND REPAIRS, DEMOLITION AND ELECTRICAL ELECTRICAL - McCARTHY STREET
SITE PLAN

SHEET 11 OF 33
 CITY DRAWING NUMBER
D-14917