



**DEMOLITION PLAN**  
SCALE 1:25

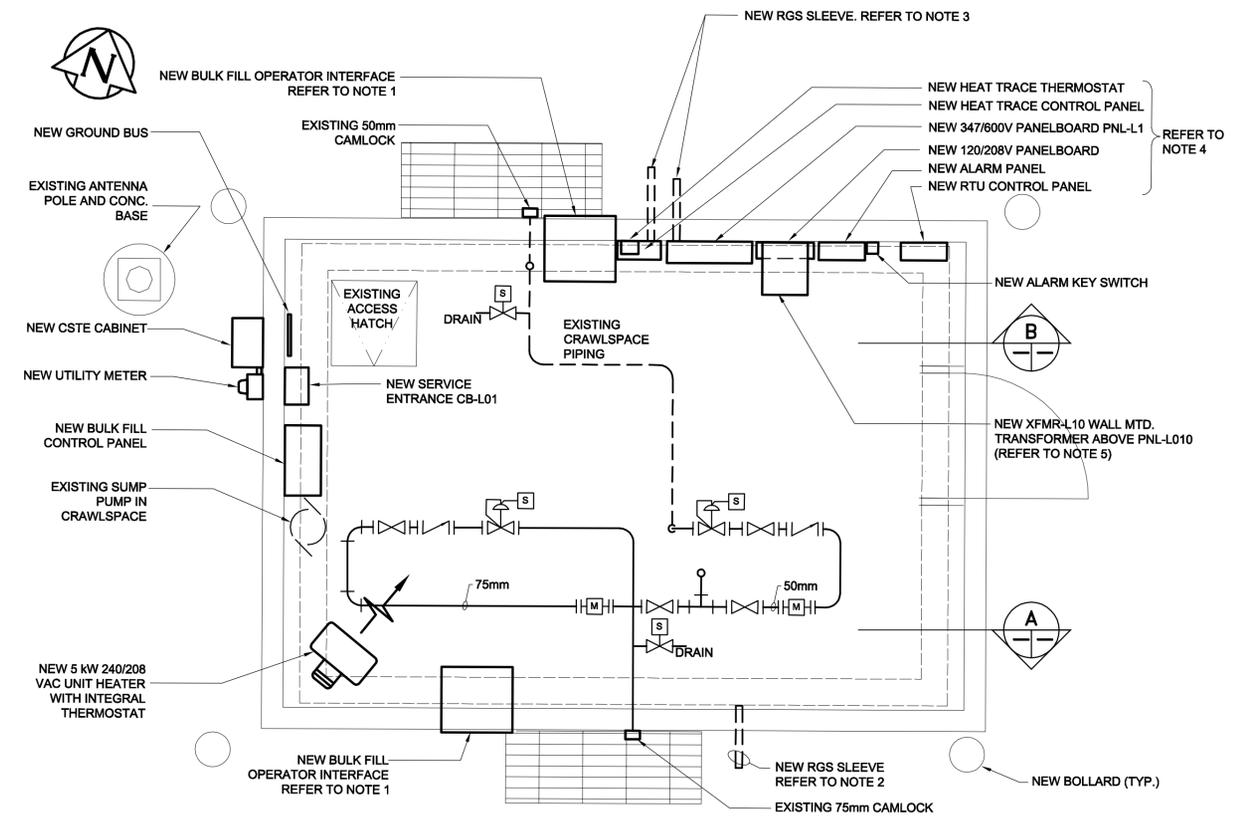


**NEW BUILDING POWER FLOOR PLAN**  
SCALE 1:25

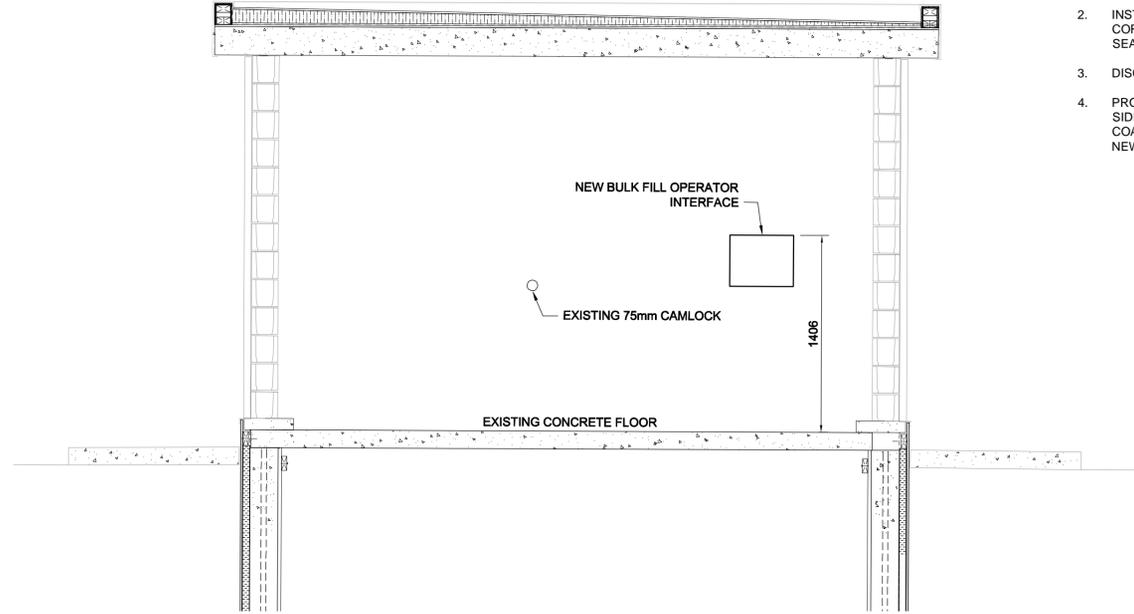

**A SECTION - SOUTH**  
SCALE 1:25

- CONSTRUCTION NOTES**
1. BULK FILL OPERATOR INTERFACE TO BE RECESSED MOUNTED. CUT NEW OPENING IN WALL.
  2. INSTALL RGS SLEEVES FOR HEAT TRACE CABLES. CORE OPENINGS THROUGH FOUNDATION WALL AND SEAL OPENING.
  3. DISCONNECT CABLES AND REMOVE PANELS.
  4. PROVIDE WALL MOUNTED 21mm THICK, GOOD ONE SIDE, PLYWOOD BACKBOARD PAINTED WITH MIN. 2 COATS WHITE PAINT, FOR SURFACE MOUNTING OF NEW ELECTRICAL EQUIPMENT AND ENCLOSURES.

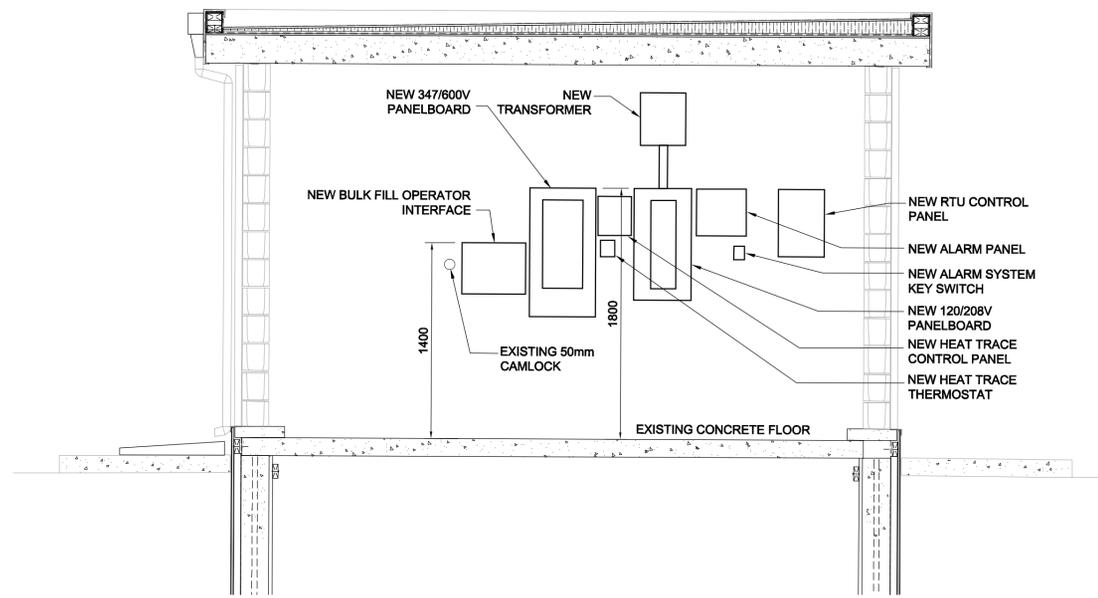

**B SECTION - NORTH**  
SCALE 1:25

FILENAME: C:\PROJECTS\WORKING\_DIRECTORY\ACTIVE\_40SK\175009-06A-SHT-CHEV-PWR.DWG PLOTTED BY: KOWALSKI, STANLEY  
 PLOT DATE: 2017-11-24 @ 8:55:34 AM PLOT SCALE: 1:1.0008 PLOT STYLE: FULL-COLOR.CTB



**LOCATION APPROVED**  
UNDERGROUND STRUCTURES

SUPV. U/G STRUCTURES COMMITTEE DATE

NOTE:  
LOCATION OF UNDERGROUND STRUCTURES AS SHOWN ARE BASED ON THE BEST INFORMATION AVAILABLE BUT NO GUARANTEE IS GIVEN THAT ALL EXISTING UTILITIES ARE SHOWN OR THAT THE GIVEN LOCATIONS ARE EXACT. CONFIRMATION OF EXISTENCE AND EXACT LOCATION OF ALL SERVICES MUST BE OBTAINED FROM THE INDIVIDUAL UTILITIES BEFORE PROCEEDING WITH CONSTRUCTION.

B.M. ELEV.	CONSTRUCTION COMPLETION DATE: YYYY MM DD		
DESIGNED BY	B.L.M.	CHECKED BY	XX
DRAWN BY	S.C.K.	APPROVED BY	XX
HORIZONTAL SCALE:	AS SHOWN	RELEASED FOR CONSTRUCTION	
VERTICAL SCALE:		DATE	2017 07 07
DATE	2017 11 24	DATE	

**DILLON CONSULTING**

ENGINEER'S SEAL  
PROVINCE OF MANITOBA  
Nov 23 2017  
B.L. MOORE  
REGISTERED PROFESSIONAL ENGINEER

CONSULTANT DRAWING NUMBER  
E-02

**THE CITY OF WINNIPEG**  
WATER AND WASTE DEPARTMENT  
ENGINEERING DIVISION

2017 REHABILITATION OF PUBLIC WATER SERVICE OUTLETS: PAVEMENT WORKS, BUILDING SUPPLY AND REPAIRS, DEMOLITION AND ELECTRICAL ELECTRICAL - CHEVRIER BLVD BUILDING POWER

SHEET 6 OF 33  
CITY DRAWING NUMBER  
D-14912