


**NEW BUILDING INSTRUMENTATION PLAN**  
SCALE 1:25

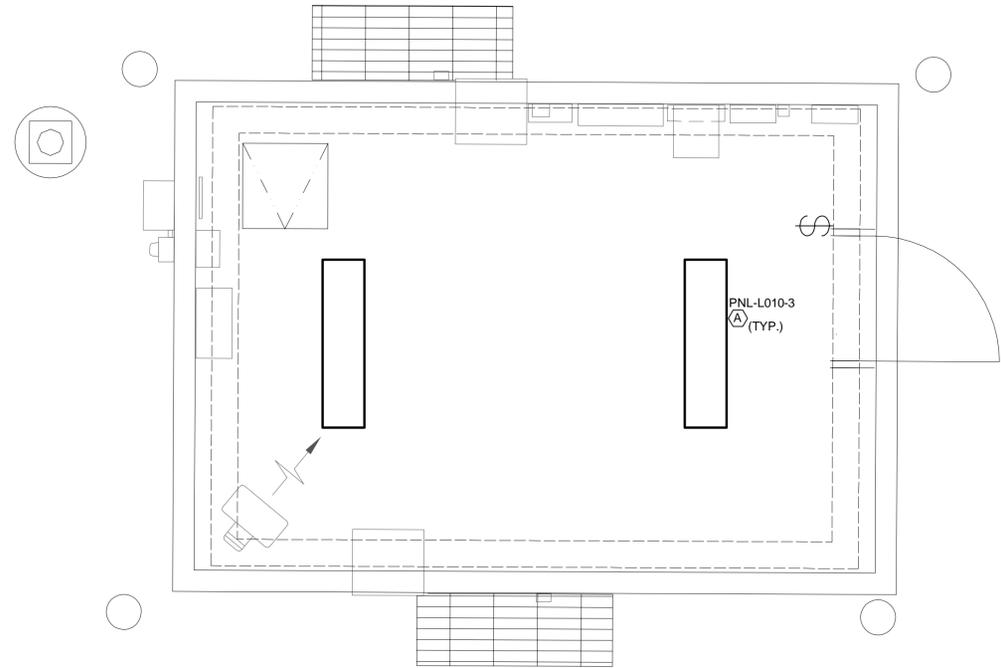

**NEW BUILDING LIGHTING FLOOR PLAN**  
SCALE 1:25

**CONSTRUCTION NOTES**

1. INSTALL NEW MAGNETIC FLOW METERS SUPPLIED BY THE CITY OF WINNIPEG. PROVIDE STRAIGHT PIPE UPSTREAM AND DOWNSTREAM AS PER MANUFACTURERS INSTRUCTIONS.

**LIGHT FIXTURE SCHEDULE**

TYPE	MODEL	MANUFACTURER	MANUFACTURER CAT. NO.	LAMP	WATTS	COLOR	REMARKS
A	COOPER-METALUX, VAPOUR TIGHT	COOPER LIGHTING	4VT2-LD4-4-DR-UNV-L835-WL-SSL	LED	38W	4000	CORROSION RESISTANT

FILENAME: C:\PROJECTS\WORKING DIRECTORY\ACTIVE\405K\10462543\175009-06B-SHT-CHEV-LTG.DWG PLOTTED BY: KOWALSKI, STANLEY  
 PLOT DATE: 2017-11-24 @ 8:56:50 AM PLOT SCALE: 1:1.0008 PLOT STYLE: FULL-COLOR.CTB



<p><b>LOCATION APPROVED UNDERGROUND STRUCTURES</b></p> <p>SUPV. U/G STRUCTURES COMMITTEE _____ DATE _____</p> <p>NOTE: LOCATION OF UNDERGROUND STRUCTURES AS SHOWN ARE BASED ON THE BEST INFORMATION AVAILABLE BUT NO GUARANTEE IS GIVEN THAT ALL EXISTING UTILITIES ARE SHOWN OR THAT THE GIVEN LOCATIONS ARE EXACT. CONFIRMATION OF EXISTENCE AND EXACT LOCATION OF ALL SERVICES MUST BE OBTAINED FROM THE INDIVIDUAL UTILITIES BEFORE PROCEEDING WITH CONSTRUCTION.</p>	<p>B.M. ELEV. _____</p> <p>CONSTRUCTION COMPLETION DATE: YYYY MM DD _____</p>		<p>ENGINEER'S SEAL</p>	<p><b>THE CITY OF WINNIPEG</b> WATER AND WASTE DEPARTMENT ENGINEERING DIVISION</p>
<p>DESIGNED BY: <b>B.L.M.</b></p> <p>DRAWN BY: <b>S.C.K.</b></p> <p>SCALE: HORIZONTAL AS SHOWN, VERTICAL AS SHOWN</p> <p>DATE: <b>2017 07 07</b></p>	<p>CHECKED BY: <b>XX</b></p> <p>APPROVED BY: <b>XX</b></p> <p>RELEASED FOR CONSTRUCTION DATE: _____</p>	<p>CONSULTANT DRAWING NUMBER: <b>E-03</b></p>	<p>2017 REHABILITATION OF PUBLIC WATER SERVICE OUTLETS: PAVEMENT WORKS, BUILDING SUPPLY AND REPAIRS, DEMOLITION AND ELECTRICAL ELECTRICAL - CHEVRIER BLVD. BUILDING - LIGHTING &amp; INSTRUMENTATION</p>	<p>SHEET <b>7</b> OF <b>33</b></p> <p>CITY DRAWING NUMBER: <b>D-14913</b></p>