

This drawing must not be scaled. The contractor shall verify all dimensions and other data on site prior to commencement of work. Discrepancies, errors, and omissions are to be reported to Public City Architecture Inc. prior to proceeding with the Work.

Drawings and specifications as instruments of service are the property of Public City Architecture Inc. and when made, must bear their name. All prints to be returned to Public City Architecture Inc. upon request.

Project
Cornish Library Renovation

Drawing
MAIN FLOOR - LIGHTING RENOVATION LAYOUT


Drawn By
 TL
 Scale
 As noted

Reviewed By
 ATS
 Drawing No.
EL2.1

Date
 2017.11.28

Project No.
 1503a

- NOTES:**
1. PROVIDE COMBINATION SELF-CONTAINED EXIT SIGN AND EMERGENCY LIGHTING HEAD, WIRE AND CONNECT TO EXISTING LIGHTING CIRCUIT IN THE AREA.
 2. REFER TO ARCHITECTURAL REFLECTED CEILING PLAN FOR DEVICE LOCATIONS.
 3. MOUNT ON PENDANT.
 4. CENTER LIGHT OVER EXISTING STAIR UP TO MAIN FLOOR. SURFACE MOUNT.
 5. EXISTING LIGHTING TO REMAIN AND BE MAINTAINED.

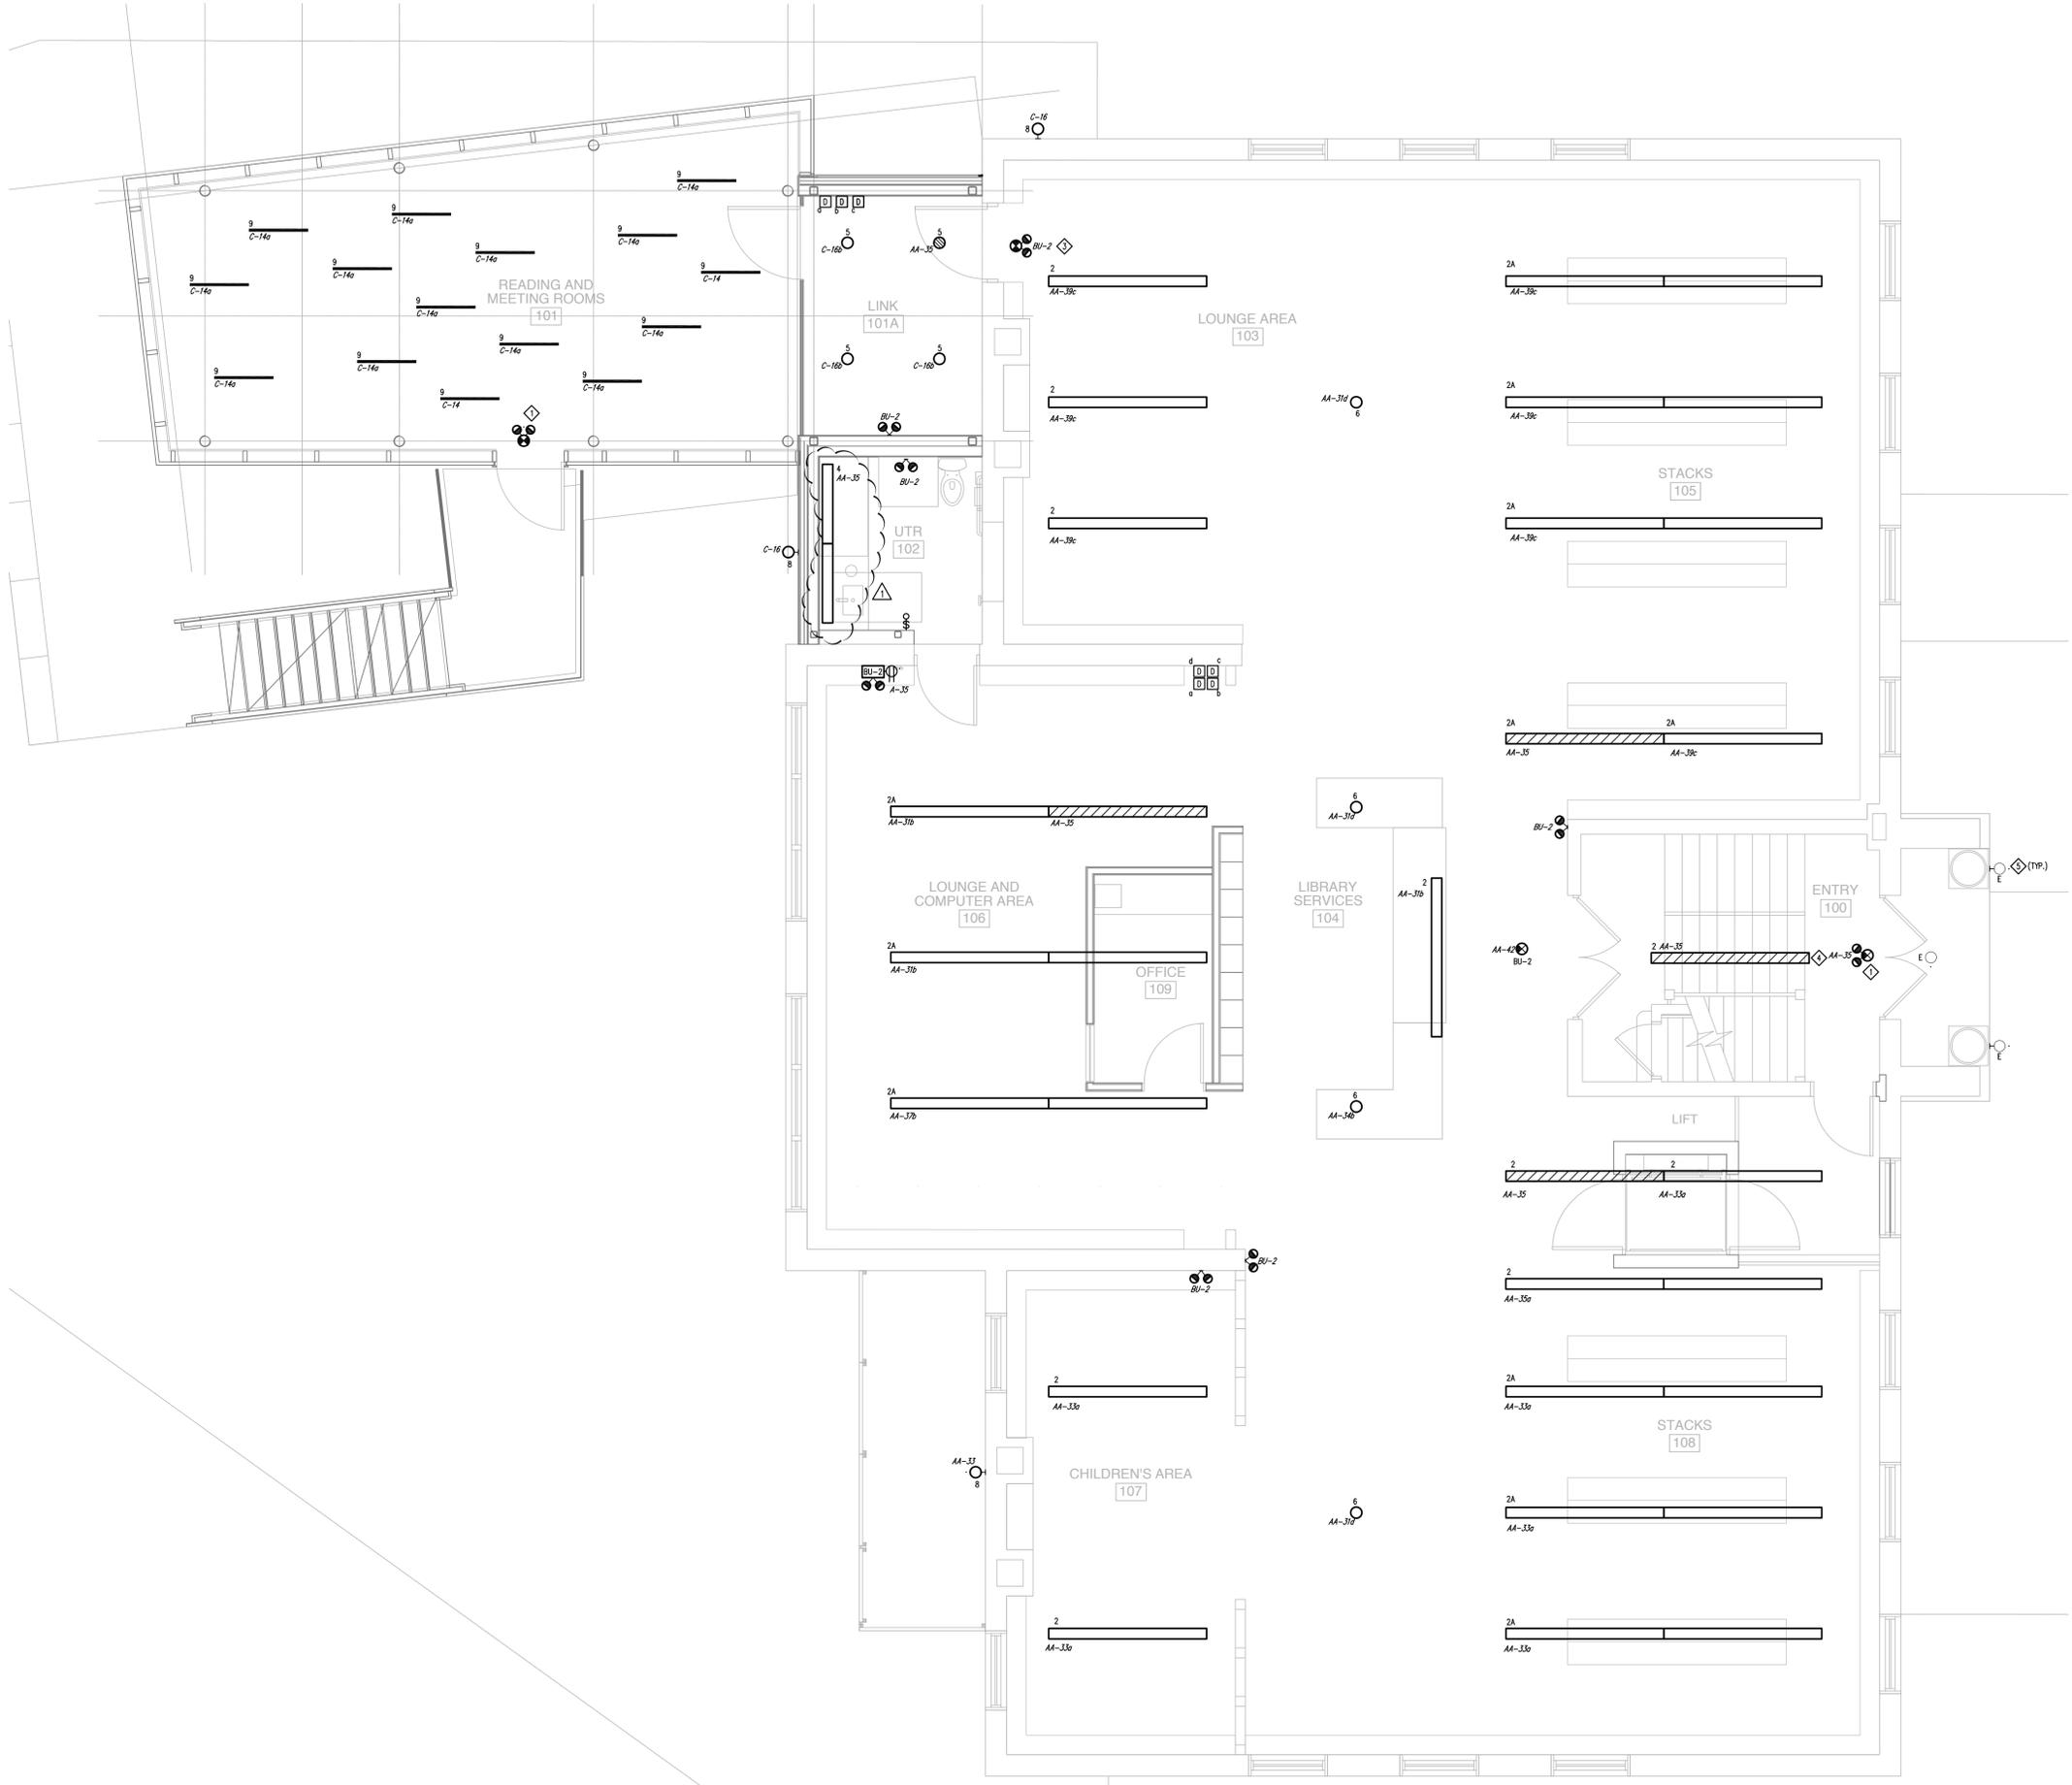

1 MAIN FLOOR - LIGHTING RENOVATION LAYOUT
 EL2.1 SCALE: 1:50