

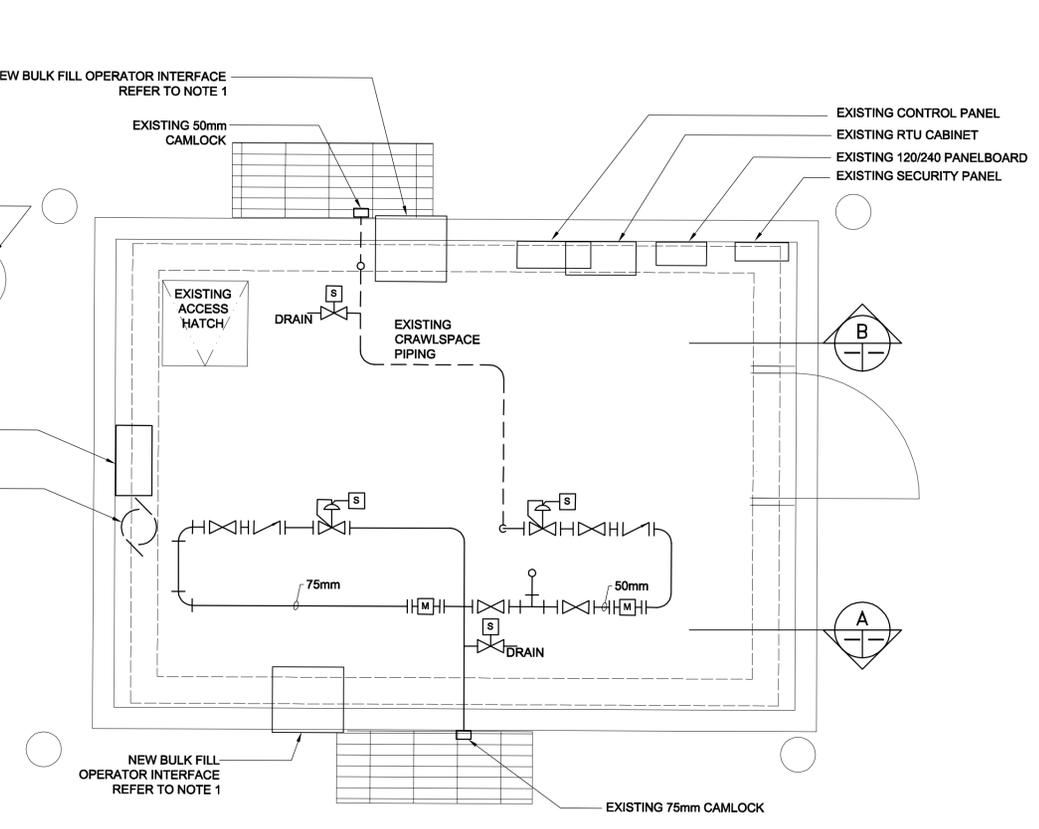



**DEMOLITION PLAN**  
SCALE 1:25

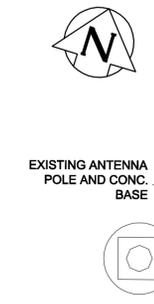

**NEW BUILDING POWER FLOOR PLAN**  
SCALE 1:25

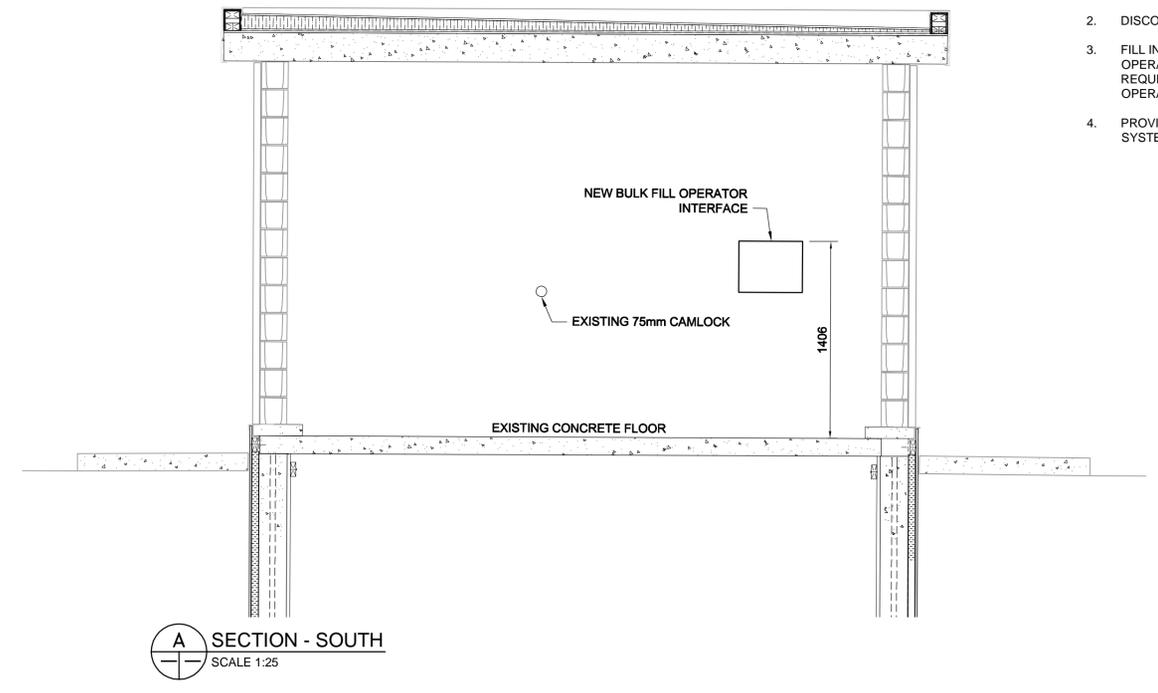

**A SECTION - SOUTH**  
SCALE 1:25

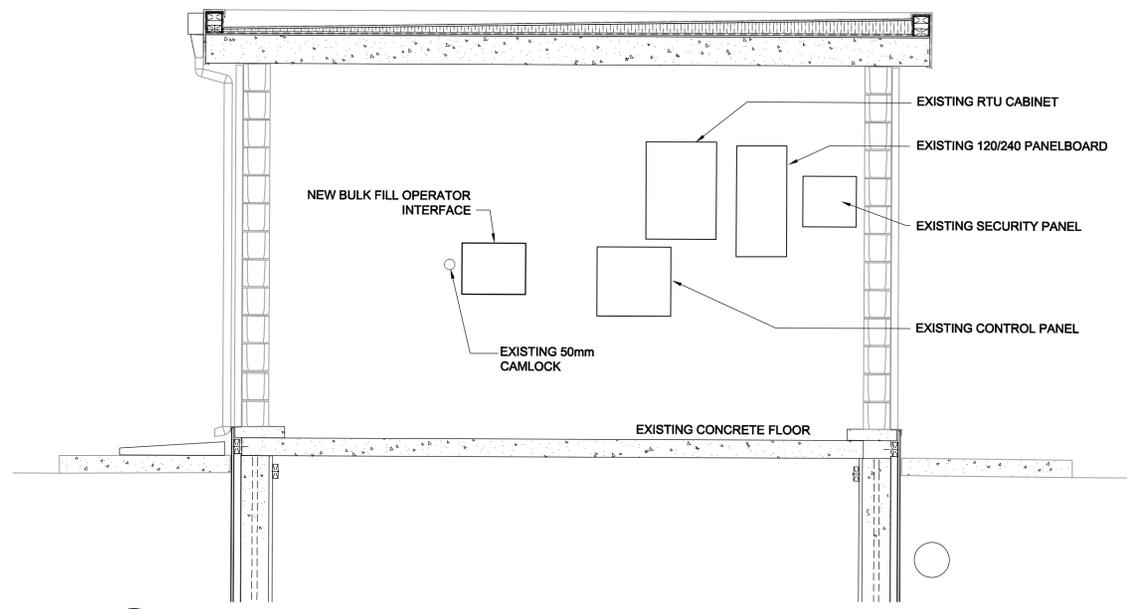

**B SECTION - NORTH**  
SCALE 1:25

- CONSTRUCTION NOTES**
1. BULK FILL OPERATOR INTERFACE TO BE RECESSED MOUNTED. CUT NEW OPENING IN WALL.
  2. DISCONNECT CABLES AND REMOVE PANELS.
  3. FILL IN OPENINGS AROUND EXISTING COIN OPERATOR PANE AND KEYGUARD PANEL AS REQUIRED TO SUIT NEW OPENINGS FOR BULKFILL OPERATOR INTERFACE PANEL.
  4. PROVIDE NEW 120VAC CIRCUITS FOR BULKFILL SYSTEM.

FILENAME: C:\PROJECTS\WORKING DIRECTORY\ACTIVE\40SK\063107\175009-06A-SHT-CHEV-PWR.DWG PLOTTED BY: KOWALSKI, STANLEY  
 PLOT DATE: 2018-07-06 @ 8:32:39 AM PLOT SCALE: 1:1.0008 PLOT STYLE: FULL-COLOR.CTB



LOCATION APPROVED UNDERGROUND STRUCTURES		B.M. ELEV.
SUPV. U/G STRUCTURES COMMITTEE	DATE	CONSTRUCTION COMPLETION DATE: YYYY MM DD
NOTE:		
LOCATION OF UNDERGROUND STRUCTURES AS SHOWN ARE BASED ON THE BEST INFORMATION AVAILABLE BUT NO GUARANTEE IS GIVEN THAT ALL EXISTING UTILITIES ARE SHOWN OR THAT THE GIVEN LOCATIONS ARE EXACT. CONFIRMATION OF EXISTENCE AND EXACT LOCATION OF ALL SERVICES MUST BE OBTAINED FROM THE INDIVIDUAL UTILITIES BEFORE PROCEEDING WITH CONSTRUCTION.		
0	ISSUED FOR BID OP 330-2018	18/04/19 B.L.M.
NO.	REVISIONS	DATE BY

<b>DILLON CONSULTING</b>	
DESIGNED BY	B.L.M. CHECKED BY XX
DRAWN BY	S.C.K. APPROVED BY XX
HORIZONTAL SCALE:	AS SHOWN
VERTICAL SCALE:	RELEASSED FOR CONSTRUCTION
DATE	2017 07 07
PLOT DATE: 2018 07 06	



<b>THE CITY OF WINNIPEG</b> WATER AND WASTE DEPARTMENT ENGINEERING DIVISION	
REHABILITATION OF PUBLIC WATER SERVICE OUTLETS: BILLING SYSTEM, BUILDING SUPPLY, DEMOLITION AND ELECTRICAL ELECTRICAL - CHEVRIER BLVD BUILDING POWER	
SHEET 3 OF 18 CITY DRAWING NUMBER	D-14912