



NOTE:  
 1) THE CONTRACTOR WILL DEMOLISH THE PUMPS, PIPING, EQUIPMENT/FITTINGS AS MARKED  
 2) THE CONTRACTOR SHALL RETURN THE DESIRED DEMOLISHED MATERIAL TO THE CITY AND DISPOSED OF THE REMAINING MATERIAL AT APPROVED LOCATION.

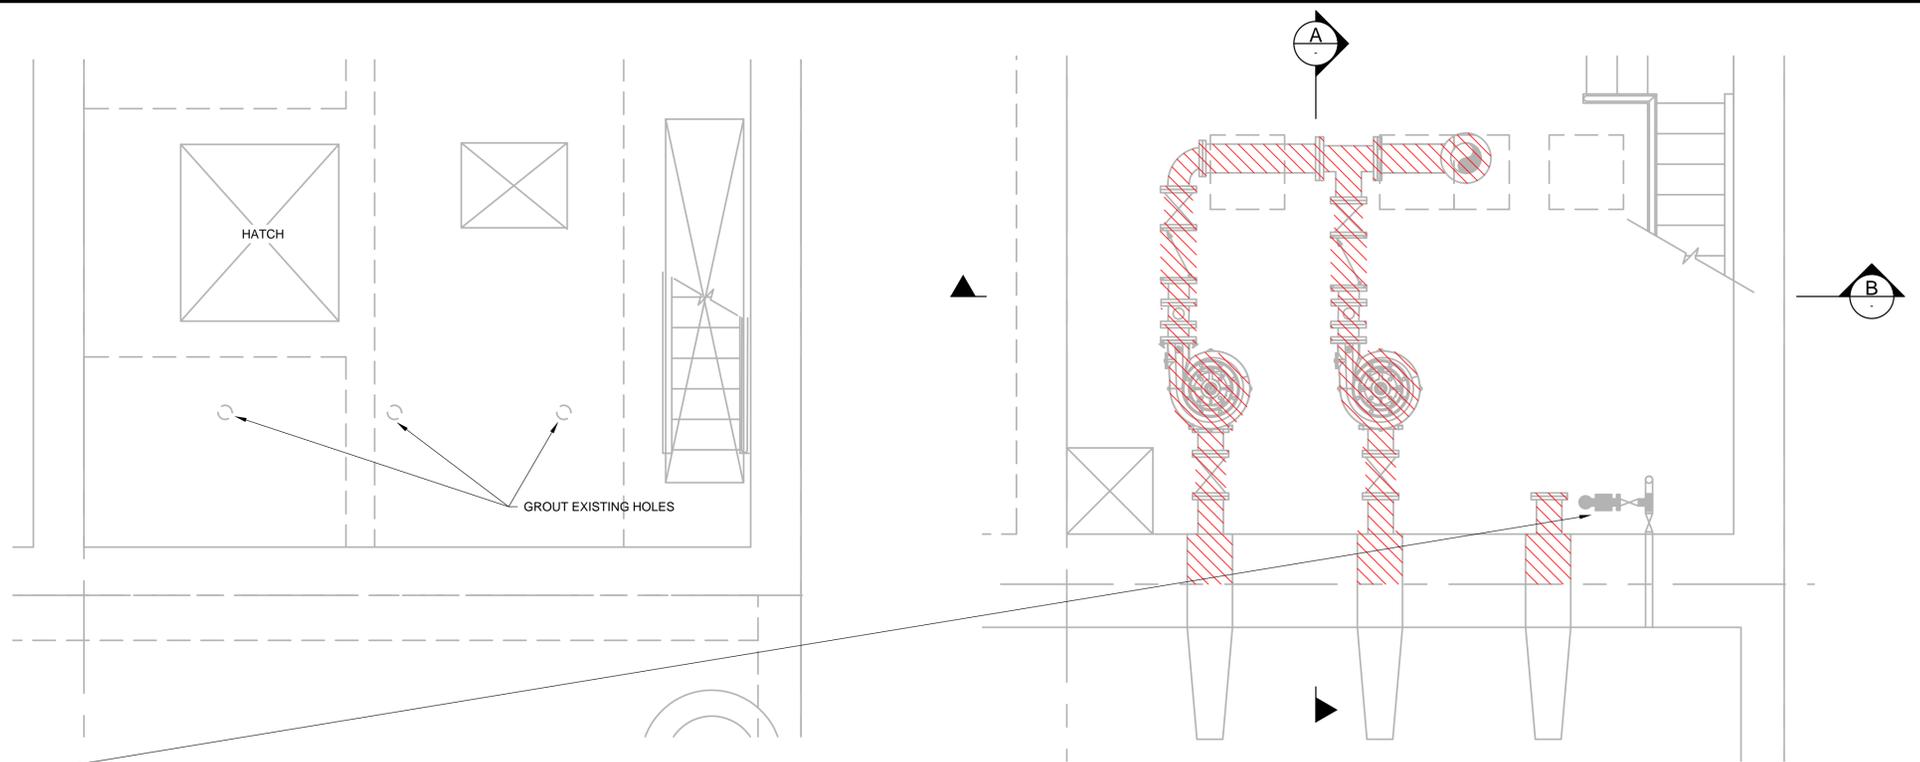


1 PARTIAL PUMP MOTOR ROOM FLOOR PLAN  
 1:25

2 PARTIAL PUMP ROOM FLOOR PLAN  
 1:25

EXISTING DP LEVEL MEASUREMENT SYSTEM TO BE REPLACED AND MODIFIED

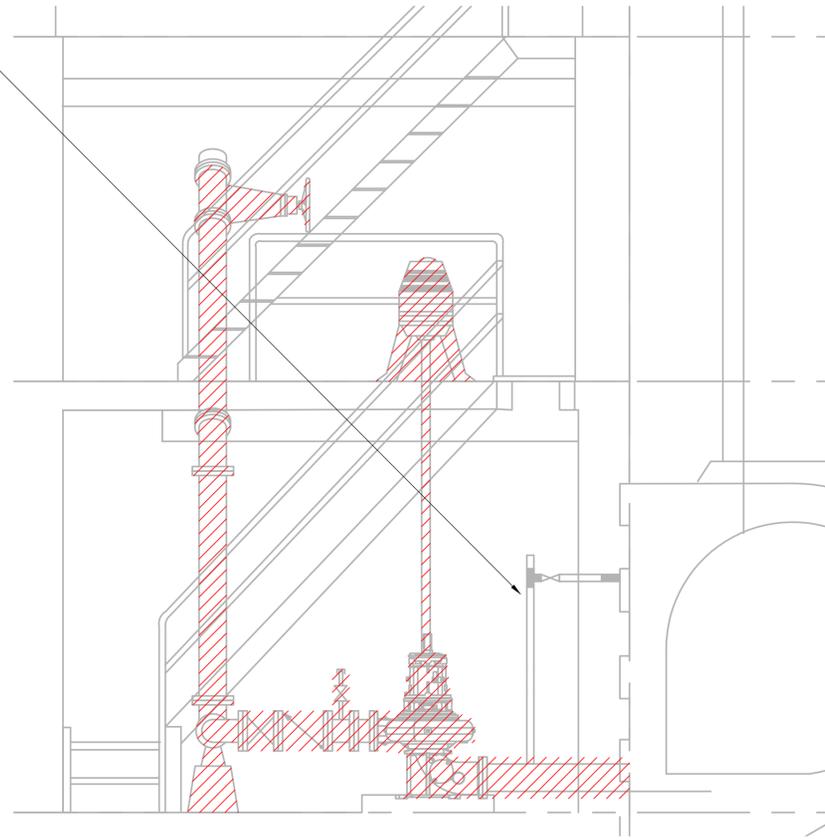

A SECTION  
 1:25

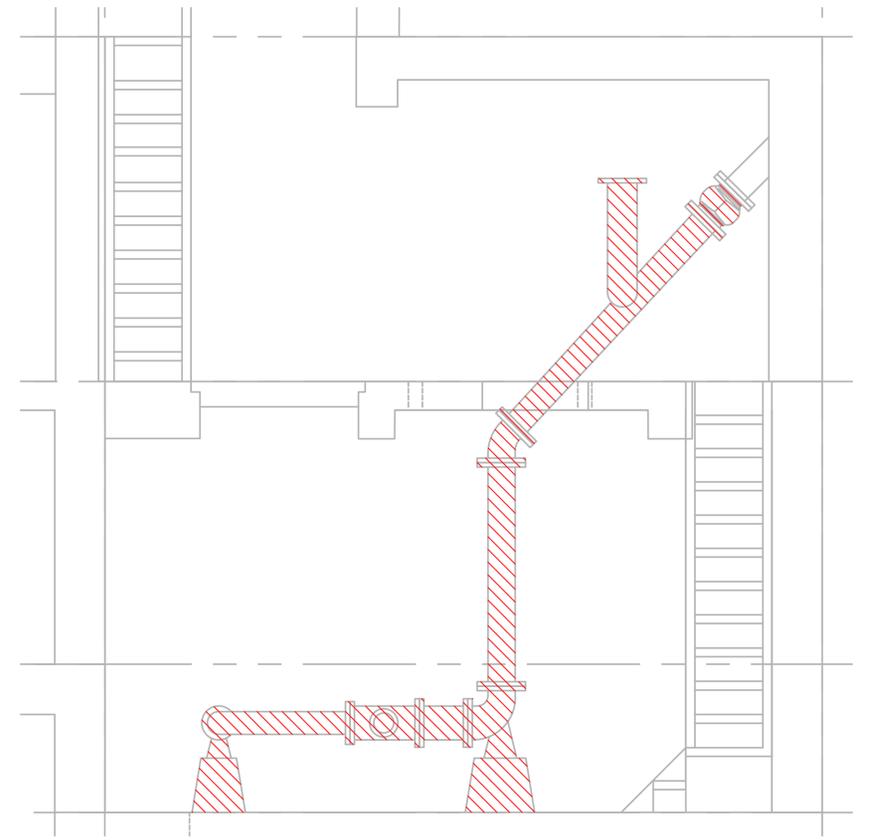

B SECTION  
 1:25

28 June 2018

186936-10-WWW-COM-F01.dwg

NOT FOR CONSTRUCTION



NO.	REVISIONS	DATE	BY
0	ISSUED FOR TENDER	06/29/18	CP

		DESIGNED BY	CP	CHECKED BY	MH
		DRAWN BY	GLG	APPROVED BY	MH
HOR. SCALE		AS SHOWN		NOT RELEASED FOR CONSTRUCTION	
VERTICAL		AS SHOWN			
DATE		June 2018		DATE	

ENGINEER'S SEAL
CONSULTANT PROJECT NUMBER
18-6936

		<b>THE CITY OF WINNIPEG</b> WATER AND WASTE DEPARTMENT	
<b>HAWTHORNE WASTEWATER PUMPING STATION UPGRADES</b>		CITY DRAWING NUMBER 1-0145L-P0001-001	
PROCESS - DEMOLITIONS		SHEET 12 OF 21 CONSULTANT DRAWING NUMBER P-01	