

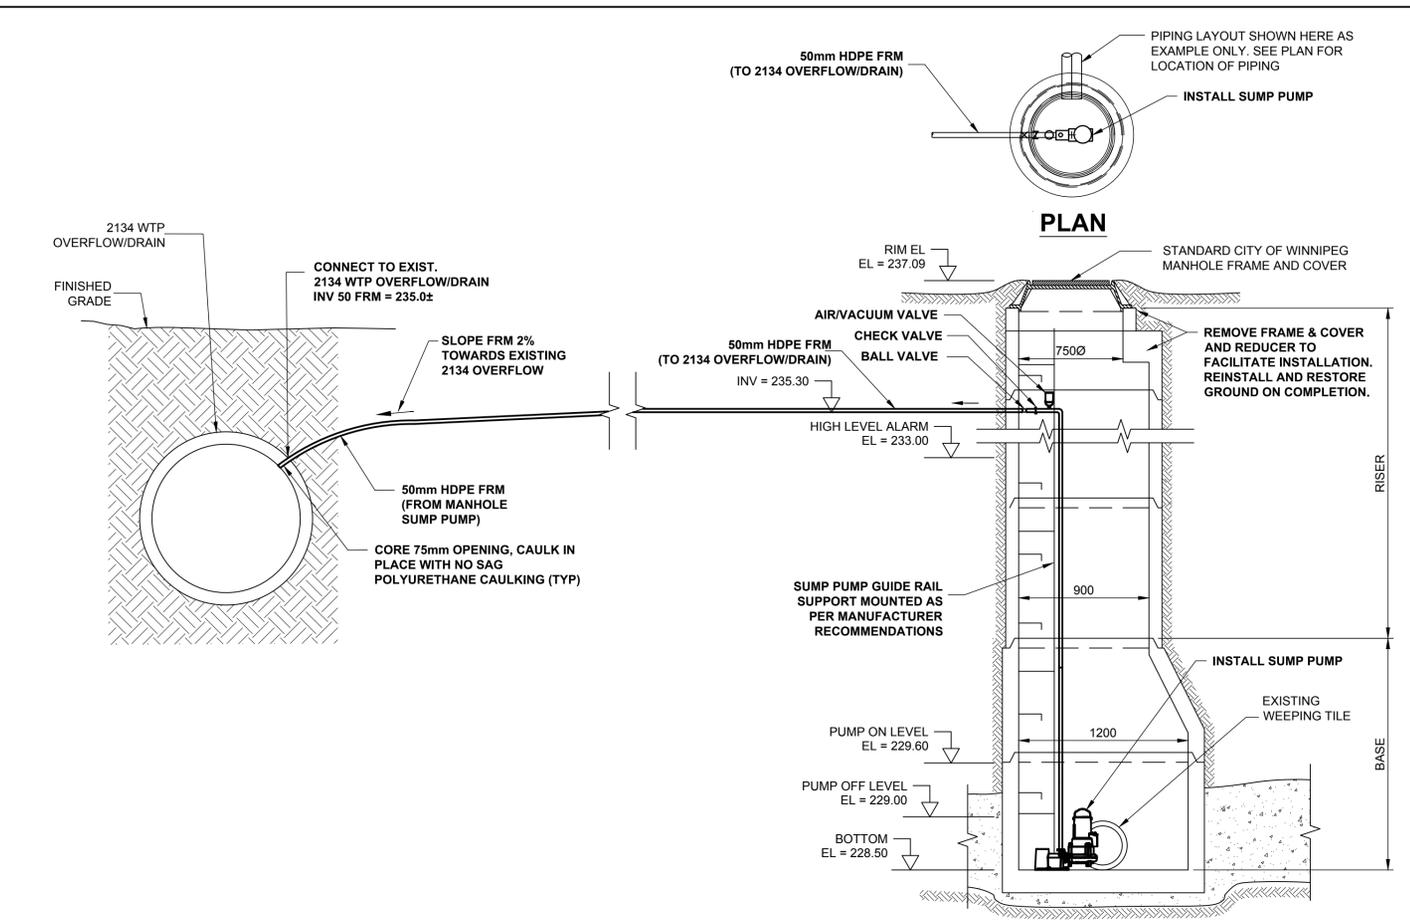


LAST SAVE: 2022/09/08 11:23 AM
 PATH: L:\D\Projects\WTR0608946_900_CD_GIS\10_CAD\SH\10608946-SHT-C-0001.dwg

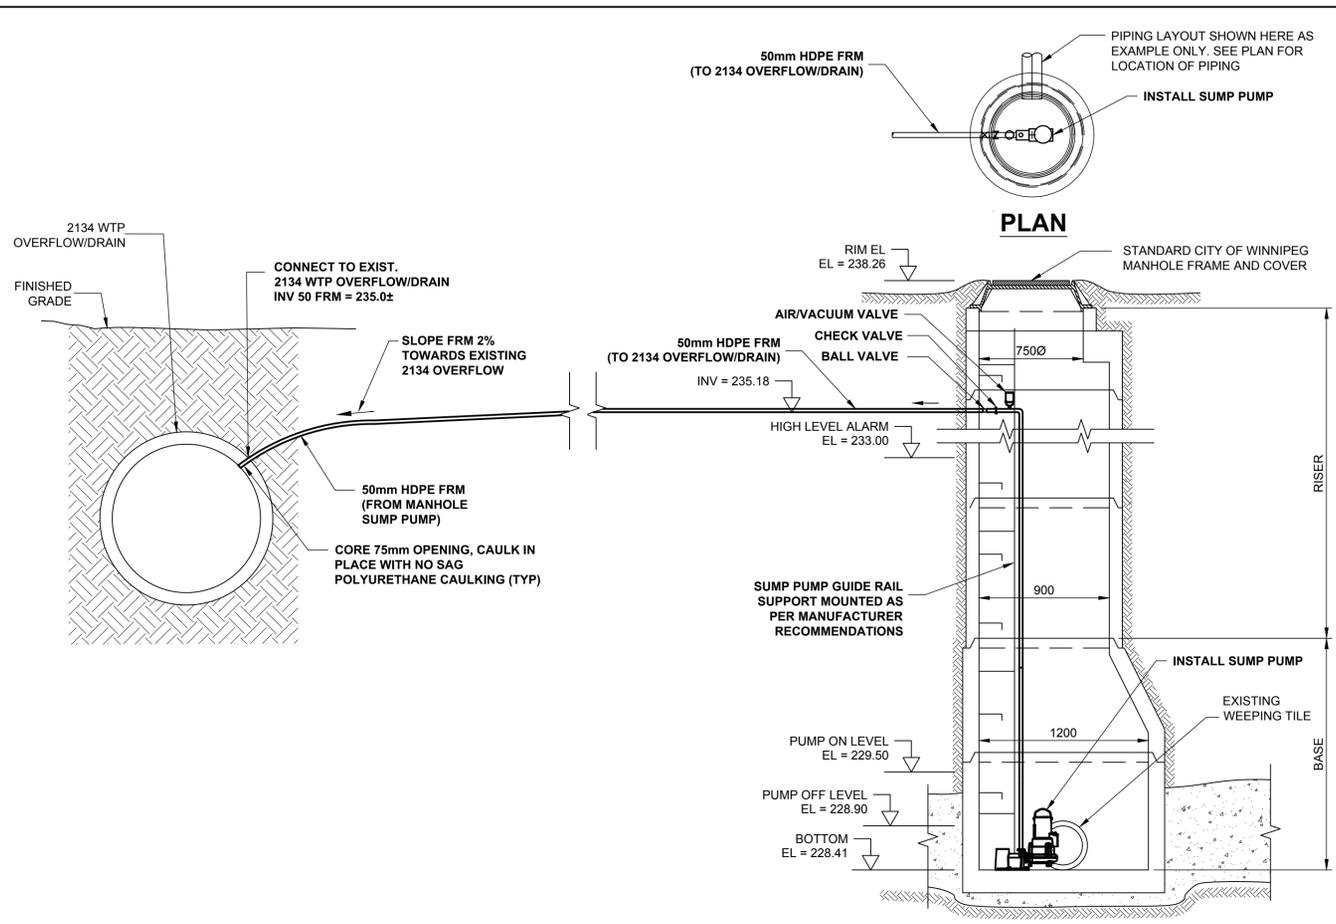


MANHOLE - FOR DETAIL
Scale NTS


MANHOLE - RWPS DETAIL
Scale NTS

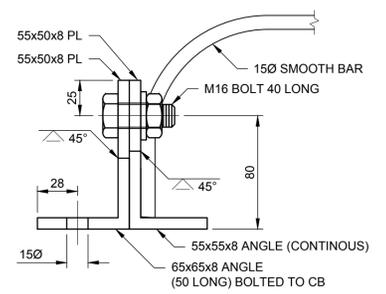


GRATE ATTACHMENT
Scale 1:2.5

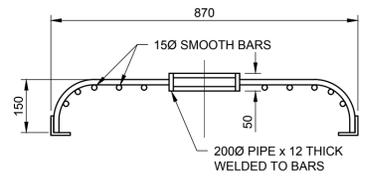


A SECTION
Scale 1:10

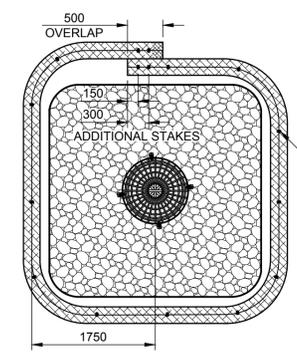

DETAIL
FIBER ROLL AT BEEHIVE DITCH INLET
Scale 1:50

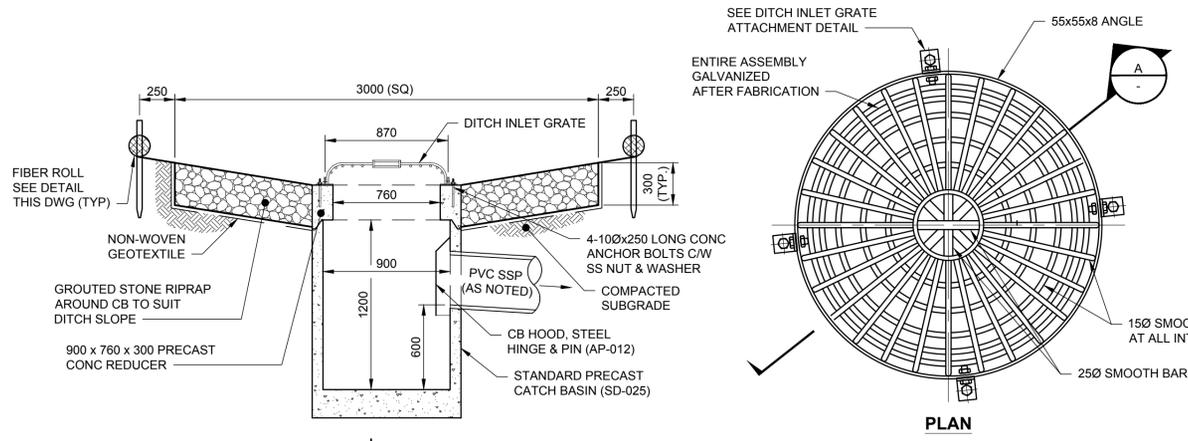

DETAIL
CATCHBASIN
Scale 1:25

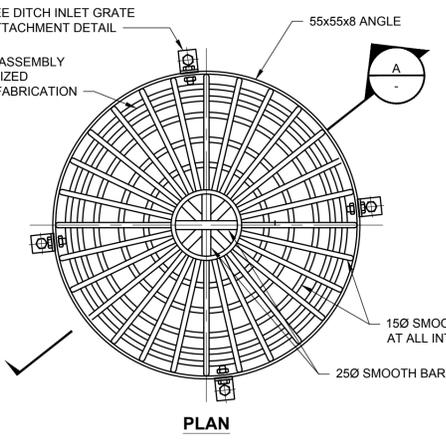

GRATE
Scale 1:10

NOTE: REFER TO DRAWINGS 1-0601D-P0001 FOR P&IDs

ENGINEERS GEOSCIENTISTS MANITOBA
Certificate of Authorization
AECOM Canada Ltd.
No. 4671 Date: 2022-09-07

NO.	REVISIONS	DATE	DESIGN	CHECK
PD	ISSUED FOR CONSTRUCTION	22/09/07	MG	MM
PC	ISSUED FOR 90%	22/07/18	MG	MM
PB	ISSUED FOR 30%	22/04/14	MG	MM
PA	ISSUED FOR 30% REVIEW	22/02/25	MG	MM

AECOM	
DESIGNED BY: MG	CHECKED BY: MCM
DRAWN BY: JP	APPROVED BY: KWF
SCALE: AS SHOWN	RELEASED FOR CONSTRUCTION BY: MATTHEW SKINNER
DATE: 2022-09-07	DATE: SEPT 8, 2022
CONSULTANT NO.:	C-0004

ORIGINAL SIGNED
BY M.P.A
GAUDREAU
SEPTEMBER 7,
2022

THE CITY OF WINNIPEG
WATER AND WASTE DEPARTMENT

WATER TREATMENT PLANT - FLOOD PROTECTION
WATER TREATMENT PLANT
CIVIL
WTP UNDERDRAIN DEWATERING MANHOLES

CITY DRAWING NUMBER
1-0601B-C0004-001

SHEET
005

REV.
PD

SIZE
A1

METRIC
WHOLE NUMBERS INDICATE MILLIMETRES
DECIMALIZED NUMBERS INDICATE METRES

TENDER NO. 672-2022