




AS SIZE 594mm x 841mm

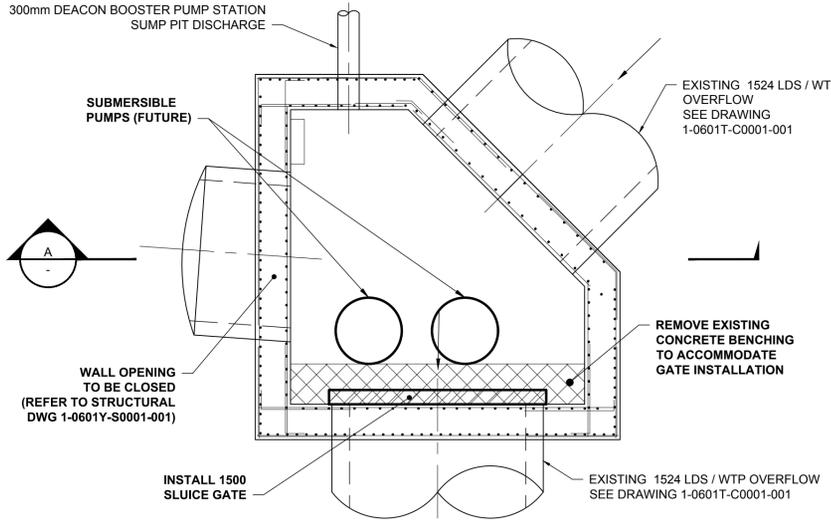

PLAN
MANHOLE No. 1

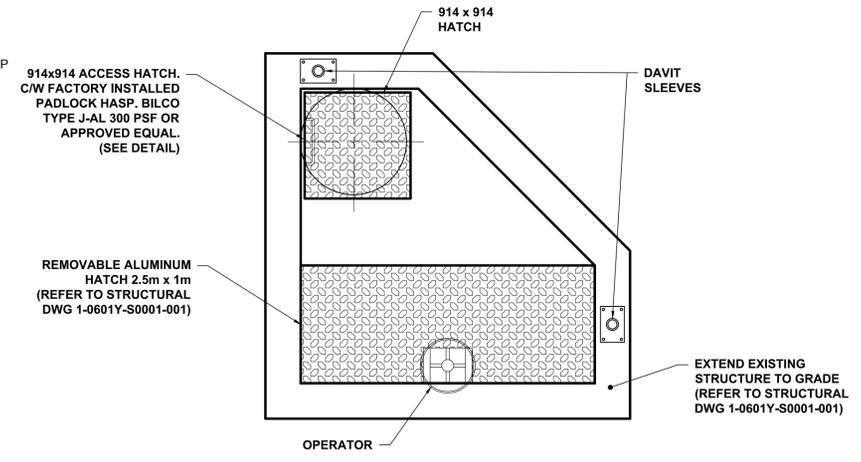


ROOF PLAN
MANHOLE No. 1

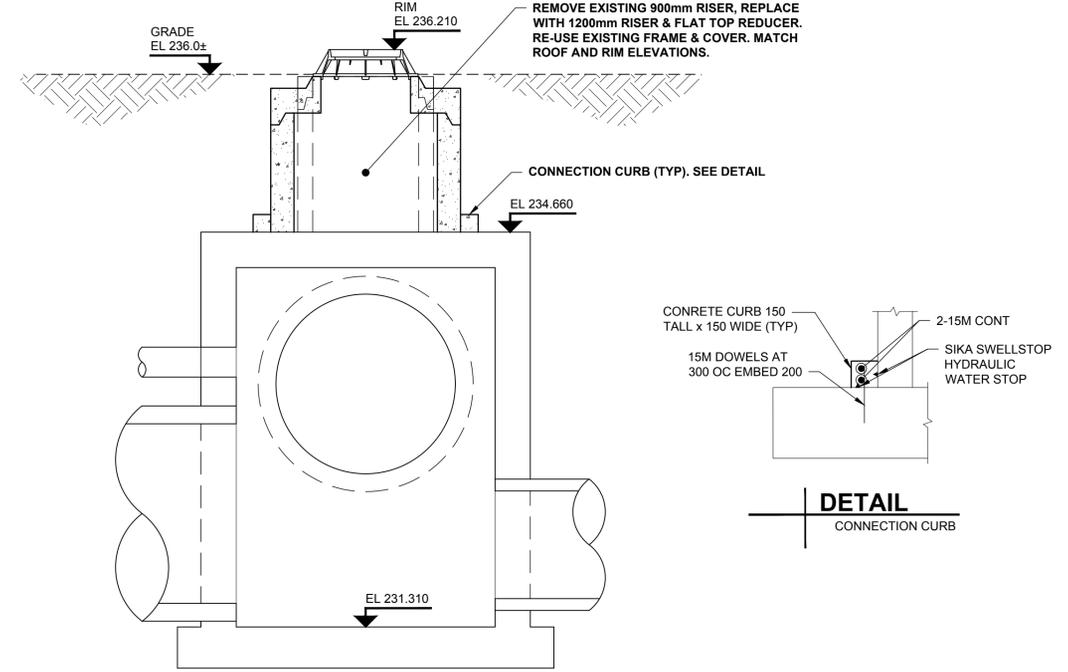


SECTION
MANHOLE No. 2


DETAIL
CONNECTION CURB

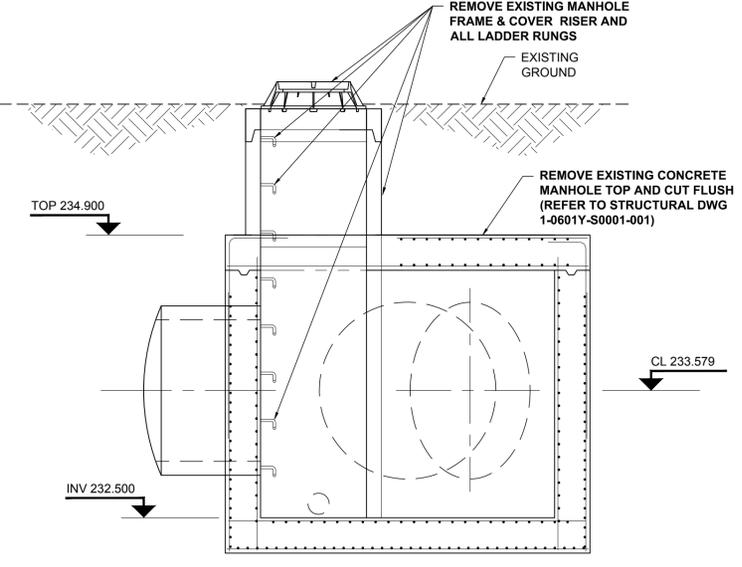


A SECTION (DEMOLITION)
MANHOLE No. 1

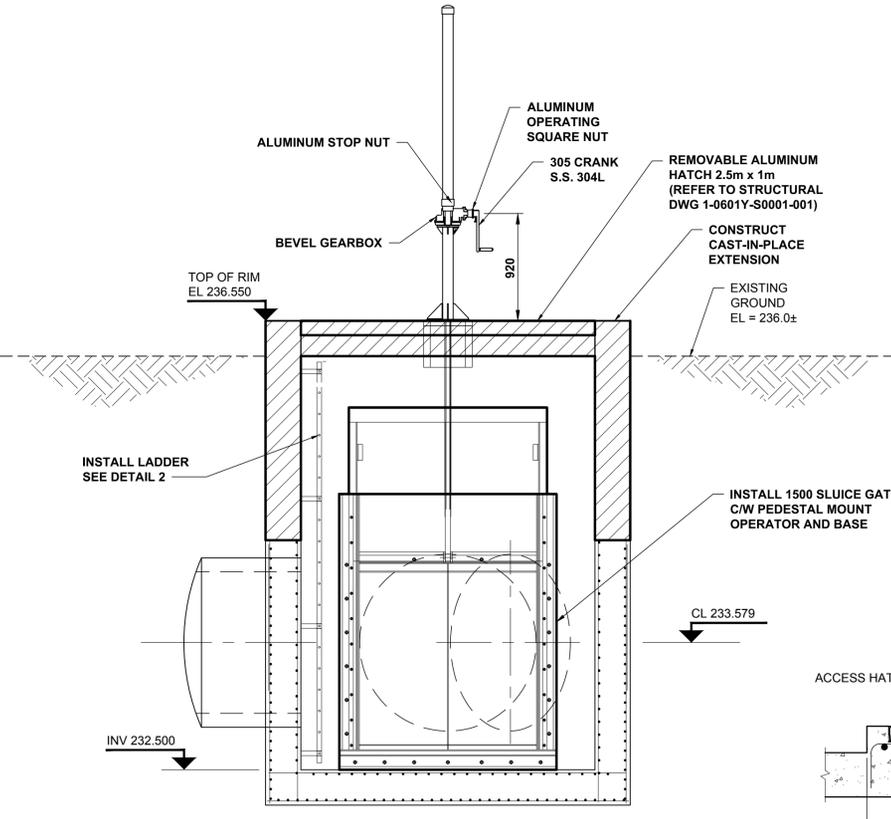

A SECTION
MANHOLE No. 1

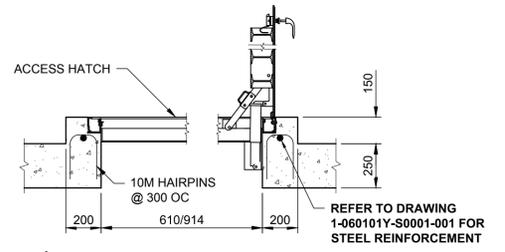

1 ACCESS HATCH SECTION

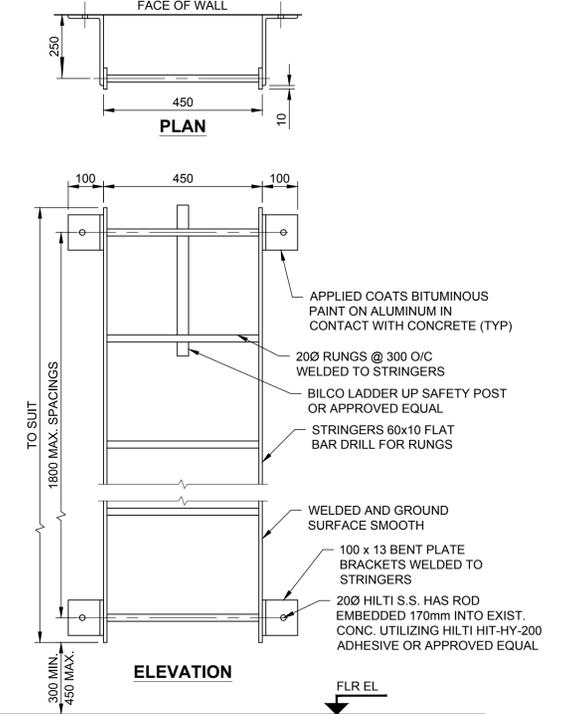

2 ALUMINUM LADDER DETAIL

TENDER NO. 672-2022

ENGINEERS GEOSCIENTISTS MANITOBA
Certificate of Authorization
AECOM Canada Ltd.
No. 4671 Date: 2022-09-07

METRIC
WHOLE NUMBERS INDICATE MILLIMETRES
DECIMALIZED NUMBERS INDICATE METRES

AECOM				DESIGNED BY: MG	CHECKED BY: MGM
				DRAWN BY: JP	APPROVED BY: KWF
PD ISSUED FOR CONSTRUCTION	22/09/07	MG	MM	SCALE: AS SHOWN	RELEASED FOR CONSTRUCTION
PC ISSUED FOR 90%	22/07/18	MG	MM	DATE: 2022-09-07	BY: MATTHEW SKINNER
PB ISSUED FOR 30%	22/04/14	MG	MM		DATE: SEPT 8, 2022
PA ISSUED FOR 30% REVIEW	22/02/25	MG	MM	CONSULTANT NO.:	C-0003
NO. REVISIONS	DATE	DESIGN	CHECK		

ENGINEER'S SEAL
ORIGINAL SIGNED
BY M.P.A
GAUDREAU
SEPTEMBER 7,
2022

THE CITY OF WINNIPEG
WATER AND WASTE DEPARTMENT

WATER TREATMENT PLANT - FLOOD PROTECTION
YARD PIPING
CIVIL
MANHOLE No. 1 AND No. 2
SECTIONS AND DETAILS

CITY DRAWING NUMBER	SHEET	REV.	SIZE
1-0601Y-C0003-001	004	PD	A1

LAST SAVE: 2022/09/08 11:23 AM
PATH: L:\DPS\Projects\WTR6000840_000_CD_GS810_CD\SHIT\0600840-SHT-C-0001.dwg