




AS SIZE - 384mm x 641mm

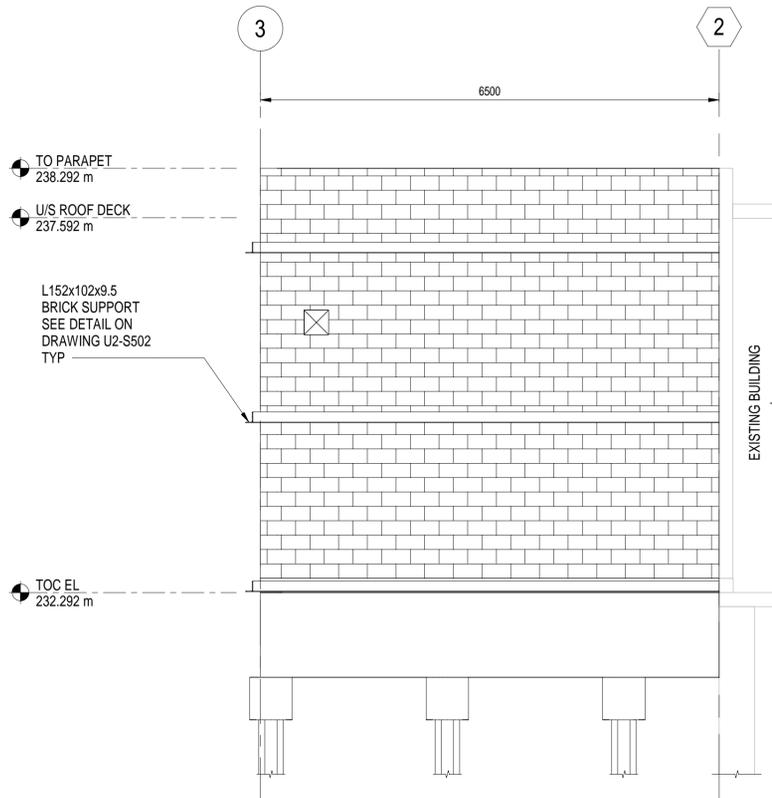


NORTH ELEVATION - NEW UV STORAGE ROOM
SCALE: 1 : 50

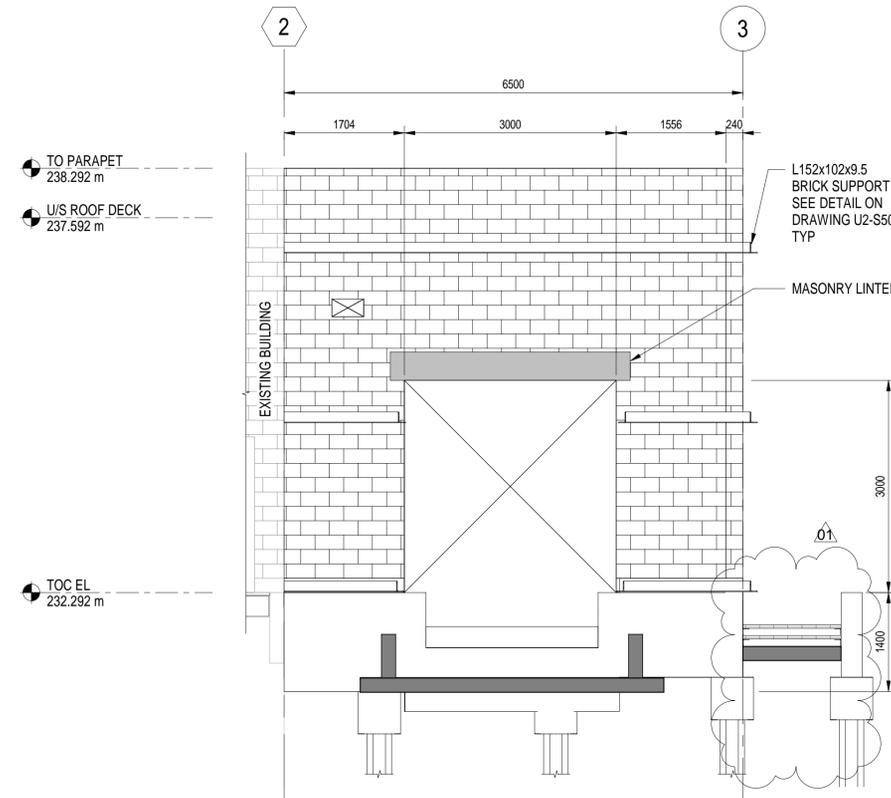


SOUTH ELEVATION - NEW UV STORAGE ROOM
SCALE: 1 : 50

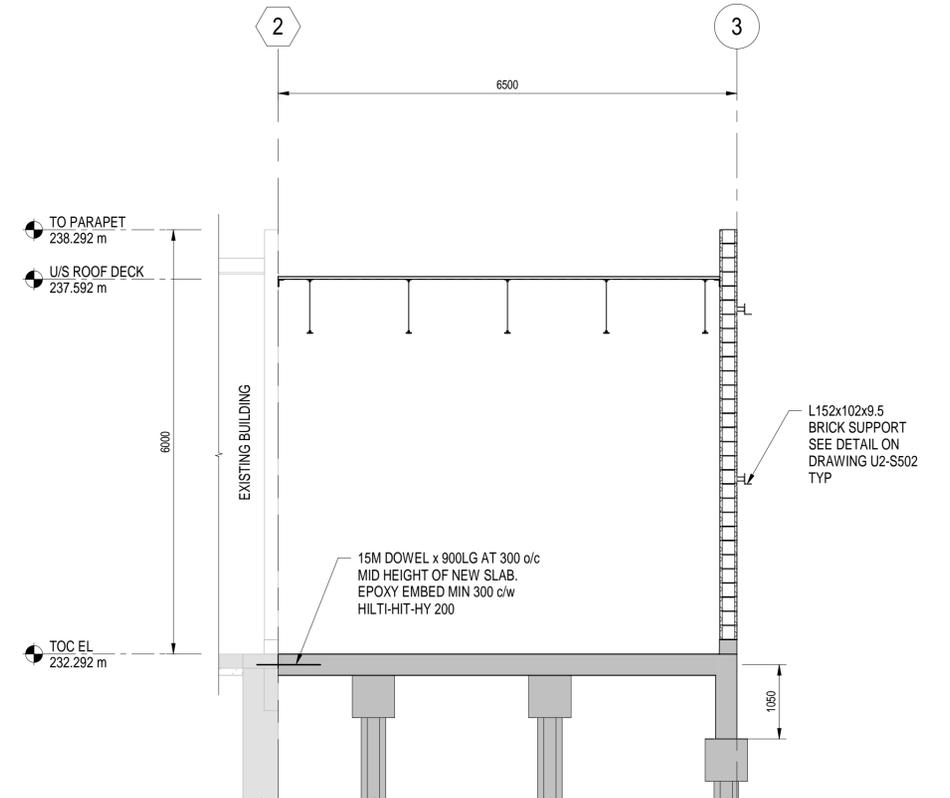

1 SECTION
U2-S102

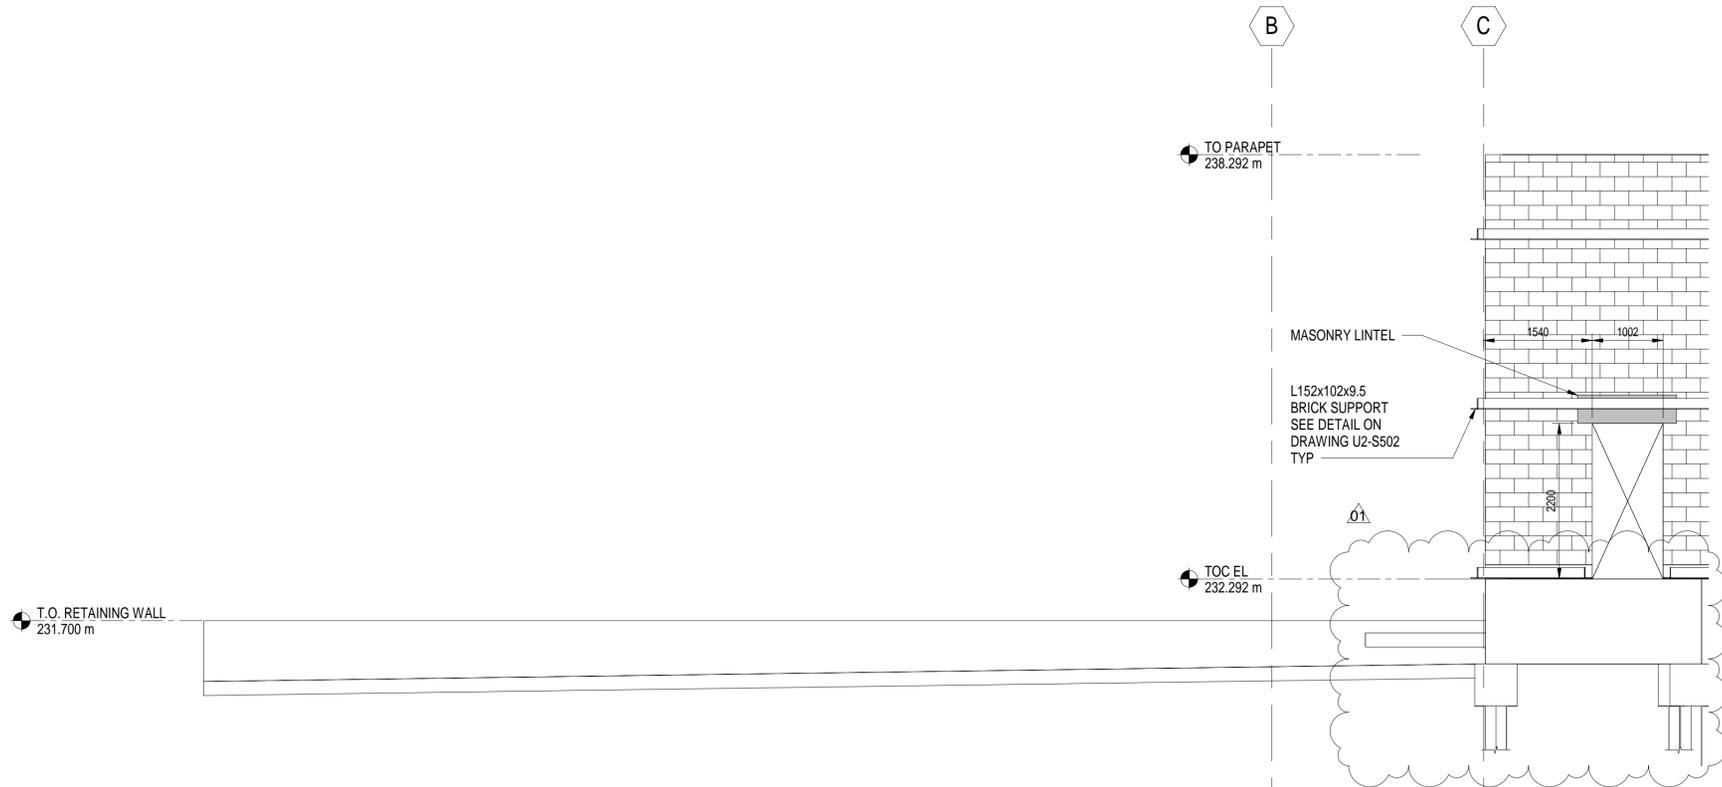

PARTIAL EAST ELEVATION - NEW UV STORAGE ROOM
SCALE: 1 : 50

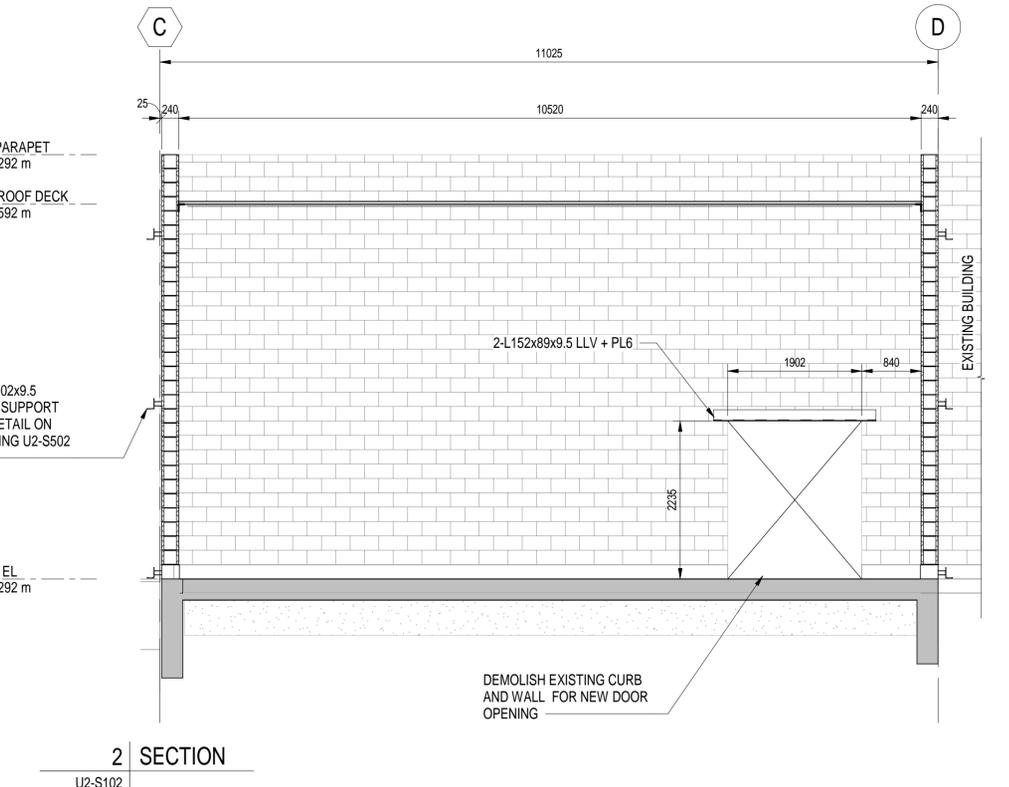

2 SECTION
U2-S102



NO.	REVISIONS	DATE	DESIGN	CHECK
01	ISSUED FOR ADDENDUM 7	2025-04-24	CT	MB
00	ISSUED FOR TENDER	2025-02-26	CT	MB
PA	ISSUED FOR 60% REVIEW	2024-09-06	MB	CK

AECOM

DESIGNED BY: MB CHECKED BY: CK
 DRAWN BY: MK APPROVED BY: NW
 SCALE: 1 : 50 RELEASED FOR CONSTRUCTION
 DATE: 2023-07-24 BY:
 CONSULTANT NO.: U2-S201 DATE:



TENDER NO. 30-2025

THE CITY OF WINNIPEG
WATER AND WASTE DEPARTMENT

NORTH END SEWAGE TREATMENT PLANT
NEWPCC UV UPGRADES
STRUCTURAL
NEW UV STORAGE ROOM
SECTIONS AND ELEVATIONS

CITY DRAWING NUMBER SHEET REV. SIZE
 01 A1

LAST SAVE: 2025-04-28 7:09:32 AM
 PATH: AutoCAD Drawings\City of Winnipeg - NEWPCC Upgrades - 2023\BMOD-U101.rvt